


BK1060CS.20

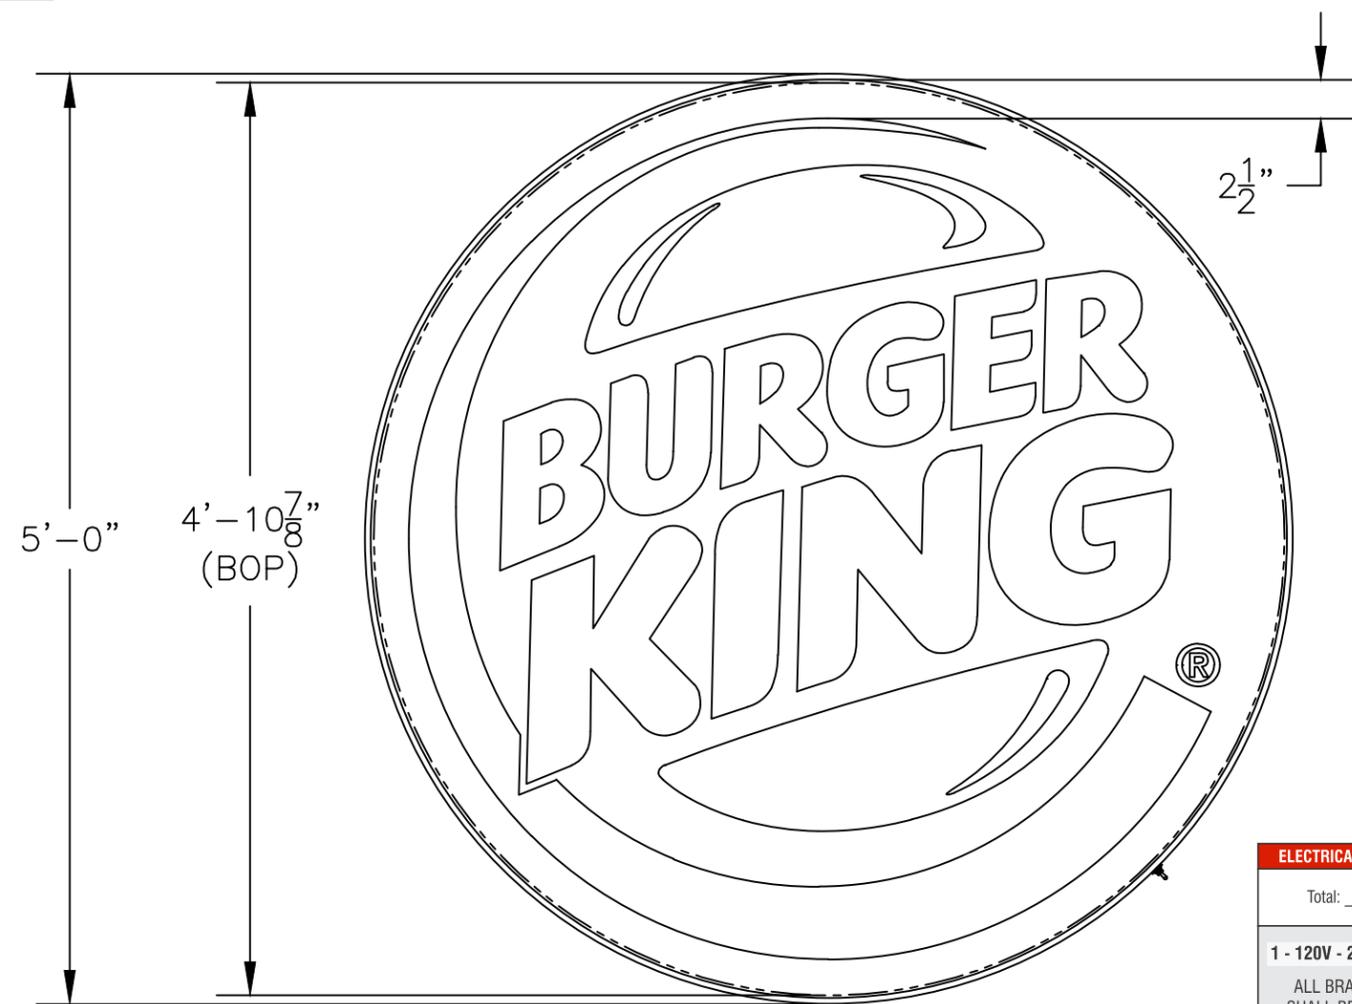


FRONT ELEVATION
SCALE: 1" = 1'-0"

LOGO
19.6 SQUARE FEET

- FORMED (VOID) .118 CLEAR FACE
- 3/8" Ø THREADED ROD w/ REQ'D BLOCKING
- WHITE GE 24V TETRA MAX LED (7100K)
- 24V GE POWER SUPPLY
- 3.5"x.040 ALUM. RETURN CONNECTOR/ CONDUIT
- SWITCH
- .090 ALUM. BACK
- 1/2"x1 1/2" DEAD SOFT RETAINER
- WEEP HOLE w/LIGHT BAFFLE

ELECTRICAL REQUIREMENTS	
Total:	.3 Amps
1 - 120V - 20A Circuits Req'd	
ALL BRANCH CIRCUITS SHALL BE DEDICATED TO	

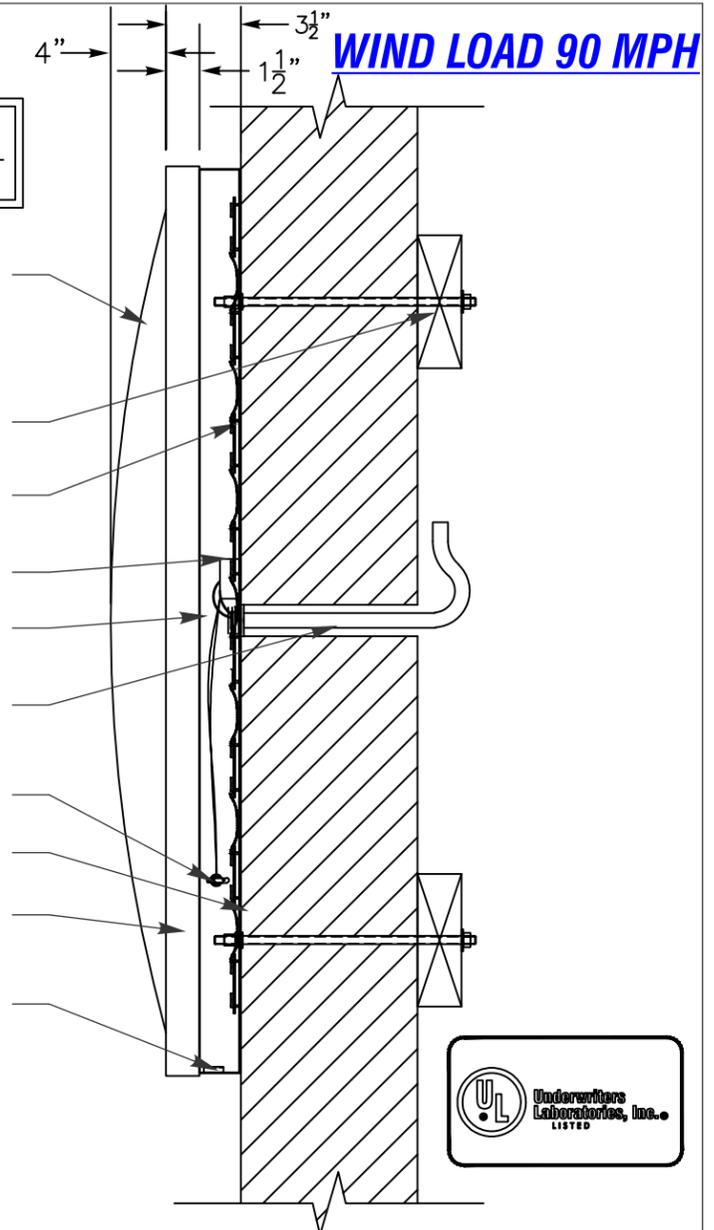

SIDE VIEW
SCALE: 1" = 1'-0"



COLOR NOTES:
 BACKS: .090 ALUM. w/ WHITE FINISH
 RETURNS/ RETAINER: 3.5"x.040 ALUM. (STAPLED & CAULKED)
 PRE-FINISHED BK SILVER/ WHITE
 FACE: FORMED (VOID) .118 CLEAR PCB
 BUN LOGO: 3M 3630-125 YELLOW
 ACCENT RING: 3M 3630-8703 BLUE
 COPY/ RTM: 3M 3630-33 RED
 BKG'D/ BUN ACCENT: 3M 3635-30 WHITE DIFFUSER
 ILLUMINATION: 24V GE TETRA MAX 7100K LED
 VINYL TO BE APPLIED 2nd SURFACE

ELECTRICAL NOTE—Actual # of circuits to be determined by a Licensed Electrical Contractor.
 TOTAL AMPS: 0.3
 # OF CKTS: 1 @ 20 AMP (RECOMMENDED)
 VOLTS: 120 or 277 (MULTI SOURCE) P.S.
 ALL SIGNAGE WILL BE (U.L.) LISTED, (U.L.) 2161 COMPLIANT AND CARRY (U.L.) LABELS.



*NOTE:
INSTALL TOGGLE SWITCH TO OPERATE (ON/OFF) IN THE HORIZONTAL POSITION.

FILE NAME: BK1060CS.20_60 DIA SF GE 24V LED CABINET **BK1060CS.20**

FEDERAL HEATH
 VISUAL COMMUNICATIONS
 www.FederalHeath.com
 12704 DuPont Circle Tampa, FL 33626
 (813) 855-4415 (800) 284-3284 Fax (813) 854-3037

Manufacturing Facilities:
 Oceanside, CA - Eules, TX - Jacksonville, TX
 Delaware, OH - Racine, WI
 Office Locations:
 Oceanside, CA - Las Vegas, NV - Laughlin, AZ
 Idaho Falls, ID - Eules, TX - Jacksonville, TX - San Antonio, TX
 Houston, TX - Corpus Christi, TX - Indianapolis, IN
 Louisville, KY - Knoxville, TN - Grafton, WI - Delaware, OH
 Willowbrook, IL - Tunica, MS - Atlanta, GA
 Tampa, FL - Daytona Beach, FL - Orlando, FL

Revisions: **R1 JCR 3/19/20 NEW SITE PLAN & ELEVATIONS**
R2 JCR 3/20/20 ADD SIGN "F"
R3 JK 5/21/20 ADD ADDITIONAL SPECIFICATIONS FOR MONUMENT SIGN (F)
R4 JK 6/05/20 CONFIRM SIGN E IS TO SCALE AND NOTE.
 Colors Depicted In This Rendering May Not Match Actual Finished Materials. Refer To Product Samples For Exact Color Match.
 Client Approval/Date: _____
 Landlord Approval/Date: _____

Account Rep: **Fiona Paul**
 Project Manager: **Jeremy Moore**
 Drawn By: **Jesthan Delcano/CHC**
 Underwriters Laboratories Inc. ELECTRICAL TO USE U.L. LISTED COMPONENTS AND SHALL MEET ALL N.E.C. STANDARDS
 ALL ELECTRICAL SIGNS ARE TO COMPLY WITH U.L. 48 AND ARTICLE 600 OF THE N.E.C. STANDARDS, INCLUDING THE PROPER GROUNDING AND BONDING OF ALL SIGNS.

Project / Location:
 Store #: 1366
 317 MAIN ST
 MADISON, NJ 07940

Job Number: 23-55534-10
 Date: September 06, 2019
 Sheet Number: 5 Of 16
 Design Number: **23-55534-10 R4**

This original drawing is provided as part of a planned project and is not to be exhibited, copied or reproduced without the written permission of Federal Heath Sign Company, LLC or its authorized agent. © FHSC