
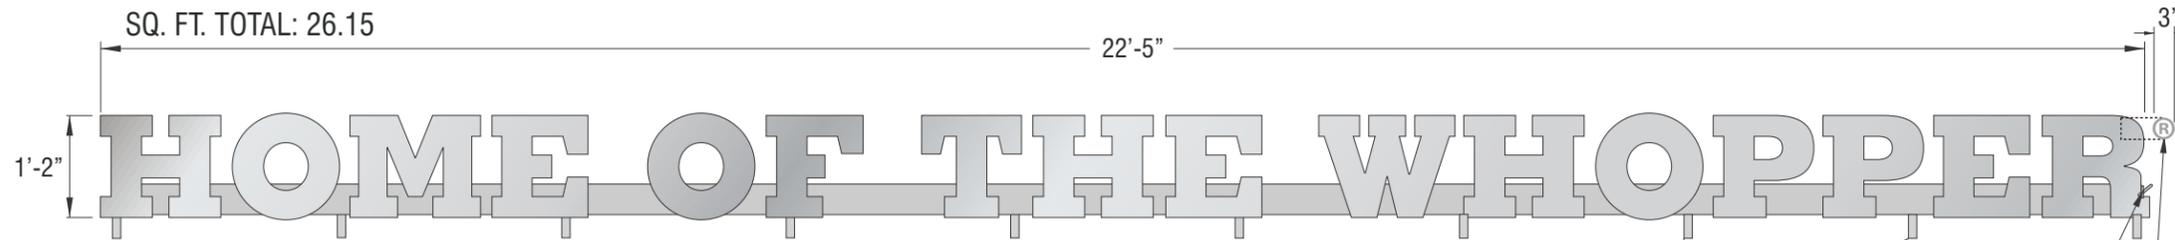
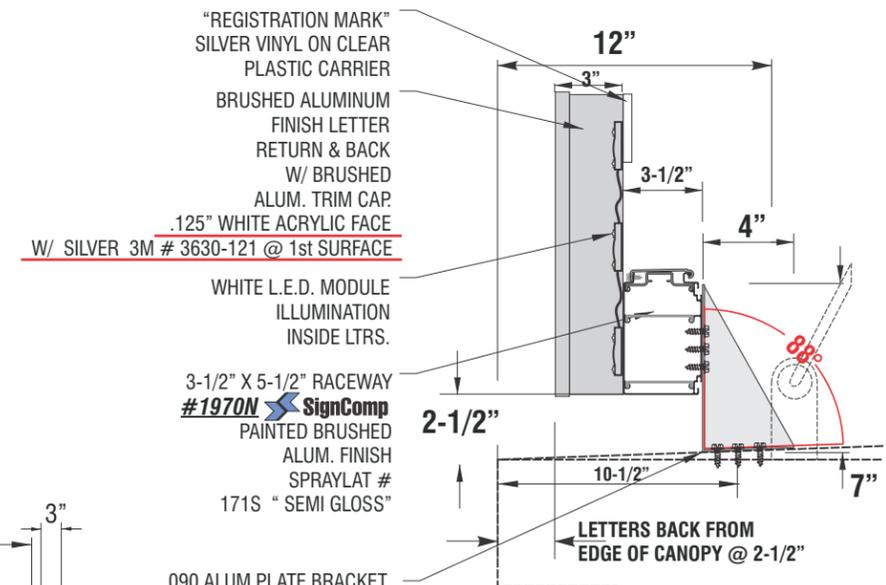


NOTE: ACTUAL LOCATION OF CENTERING LETTERS ON CANOPY WILL BE DEPICTED ON THE ACTUAL SITE ELEVATION. THIS VIEW FOR HEIGHT UP FROM CANOPY, AND LENGTH AWAY FROM EDGE OF FACE OF CANOPY.

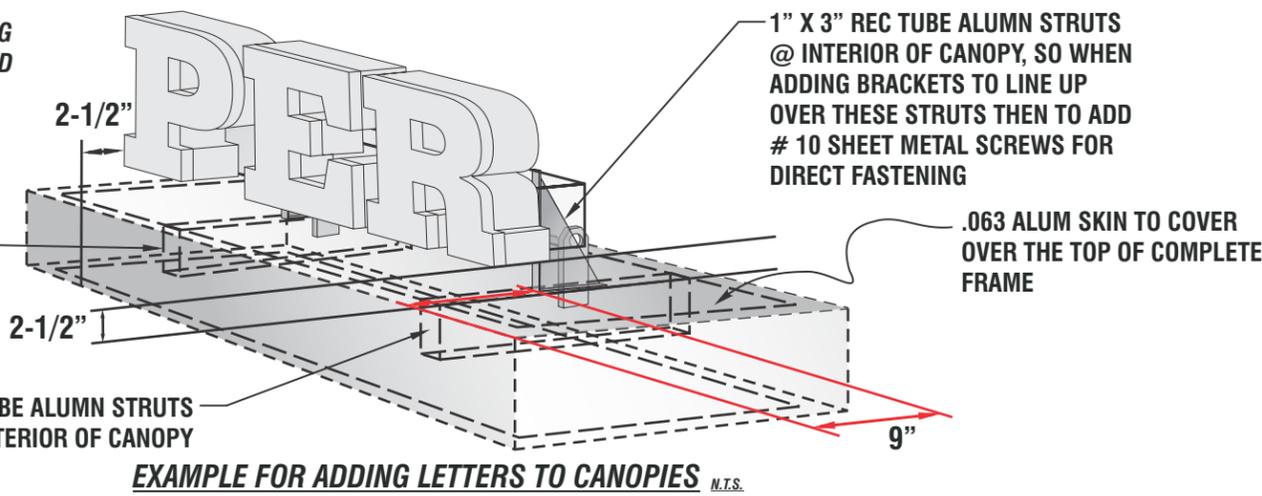

B ELEVATION OF HOME OF THE WHOPPER (DIMENSIONAL LETTERS)
 (1) ONE SET REQUIRED SCALE: 1/2" TO 1'-0"

LETTERS TO BE 3" DEEP
 FABRICATED ALUMINUM CONSTRUCTION CHANNEL LETTERS
 WITH .125" WHITE ACRYLIC FACES: APPLIED SILVER 3M # 3630-121 VINYL @ 1st SURFACE.
 LETTER RETURNS TO BE PAINTED: SPRAYLAT # 171S BRUSHED ALUM. "SEMI GLOSS"
 WITH BRUSHED ALUM. 1" TRIM CAP RETAINERS.
 "®" SILVER VINYL ON PLASTIC CARRIER ATTACHED TO BACK OF LETTER.
 LETTERS TO BE MOUNTED TO A FABRICATED RACEWAY, THEN TO AN ANGLE PLATE BRACKET FOR MOUNTING TO CANOPY.
 POWER SUPPLIES TO BE IN RACEWAY.

L.E.D. ILLUMINATION SPECIFICATIONS TO FOLLOW.

NOTE: THESE BRACKETS ARE TO BE @ CENTERS OF THE 1" X 3" ALUM TUBE STRUTS THAT ARE IN THE CANOPIES INTERIOR. TO USE REQUIRED AMOUNT. THEY ARE ONLY TO BE PLACED WHERE THERE IS A STRUT.

ON/OFF SWITCH @ END OF RACEWAY.
 SILVER VINYL ON CLEAR PLASTIC CARRIER

.090 ALUM PLATE BRACKET
 AMOUNT: (10) TEN FOR MOUNTING
 (SHOWING THE 88 DEGREE PLANE)
 PAINTED BRUSHED ALUM SPRAYLAT # 171S "SEMI GLOSS"
 PLACEMENT AS REQUIRED IN THE FIELD.
 MINIMAL NOTCHING OF THIS BRACKET MAY BE REQUIRED IN THE FIELD FOR FIT @ BRACKET AND STRUT BRACE MEET

PRIMARY ELECTRIC LOCK-OUT DISCONNECT PER NEC AND U.L. 48 STANDARDS
 SIDE VIEW
 SCALE: 1-1/2" TO 1'-0"

(1) GEPS24-100U-NA @ 1.1 AMPS



TYPICAL RIGHT ELEVATION
 SCALE = 1/8" = 1'-0"



ELECTRICAL REQUIREMENTS	
Total:	1.1 Amps
1 of 120V, 20A Circuits Req'd.	
ALL BRANCH CIRCUITS SHALL BE DEDICATED TO SIGNS (INCLUDING GROUND AND NEUTRAL) AND SHALL NOT BE SHARED WITH OTHER LOADS.	

FEDERAL HEATH
 VISUAL COMMUNICATIONS
 www.FederalHeath.com
 12704 DuPont Circle Tampa, FL 33626
 (813) 855-4415 (800) 284-3284 Fax (813) 854-3037

Manufacturing Facilities:
 Oceanside, CA - Eules, TX - Jacksonville, TX
 Delaware, OH - Racine, WI
 Office Locations:
 Oceanside, CA - Las Vegas, NV - Laughlin, AZ
 Idaho Falls, ID - Eules, TX - Jacksonville, TX - San Antonio, TX
 Houston, TX - Corpus Christi, TX - Indianapolis, IN
 Louisville, KY - Knoxville, TN - Grafton, WI - Delaware, OH
 Willowbrook, IL - Tunica, MS - Atlanta, GA
 Tampa, FL - Daytona Beach, FL - Orlando, FL

Revisions: **R1 JCR 3/19/20 NEW SITE PLAN & ELEVATIONS**
R2 JCR 3/20/20 ADD SIGN "F"
R3 JK 5/21/20 ADD ADDITIONAL SPECIFICATIONS FOR MONUMENT SIGN (F)
R4 JK 6/05/20 CONFIRM SIGN E IS TO SCALE AND NOTE.
 Colors Depicted In This Rendering May Not Match Actual Finished Materials. Refer To Product Samples For Exact Color Match.
 Client Approval/Date: _____
 Landlord Approval/Date: _____

Account Rep: **Fiona Paul**
 Project Manager: **Jeremy Moore**
 Drawn By: **Jesthan Delcano/CHC**
Underwriters Laboratories Inc. **ALL ELECTRICAL SIGNS ARE TO COMPLY WITH U.L. 48 AND ARTICLE 600 OF THE N.E.C. STANDARDS, INCLUDING THE PROPER GROUNDING AND BONDING OF ALL SIGNS.**

Project / Location: **Store #: 1366**
317 MAIN ST
MADISON, NJ 07940

Job Number: **23-55534-10**
 Date: **September 06, 2019**
 Sheet Number: **7** Of **16**
 Design Number: **23-55534-10 R4**

This original drawing is provided as part of a planned project and is not to be exhibited, copied or reproduced without the written permission of Federal Heath Sign Company, LLC or its authorized agent. © FHSC