


DESIGN INTENT ONLY
ENGINEERING REQUIRED TO DETERMINE
ACTUAL MANUFACTURING
& INSTALLATION REQUIREMENTS

COLOR NOTES:
 ILLUM. REVEAL: .125 RED PCB
 RND CAB. FILLER/ RETAINER:
 PAINT BRUSHED ALUM. SILVER
 RETAINER/EXPOSED LENS RETAINER:
 PAINT PMS 2319 (BROWN)
 MON FACE PANEL: .090" ALUM

LOGO FACE: .093 CLEAR PCB
 BUN LOGO: 3M 3630-125 YELLOW
 ACCENT RING: 3M 3630-8703 BLUE
 COPY/ RTM: 3M 3630-33 RED
 BKG'D/ BUN ACCENT: 3M 3635-30
 WHITE DIFFUSER

VINYL TO BE APPLIED 2nd SURFACE


ELECTRICAL NOTE—ACTUAL # OF CIRCUITS TO BE DETERMINED BY A LICENSED ELECTRICAL CONTRACTOR.
 TOTAL AMPS: 1.1
 # OF CKTS: 1 @ 20 AMP(RECOMMENDED)
 VOLTS: 120
 ELECTRICAL CONNECTION AS FOLLOWS:
 GREEN TO GREEN (GROUND), WHITE TO WHITE (NEUTRAL),
 BLACK TO BLACK (POWER)
 ALL SIGNAGE WILL BE (U.L.) LISTED, (U.L.) 2161 COMPLIANT
 AND CARRY (U.L) LABELS.

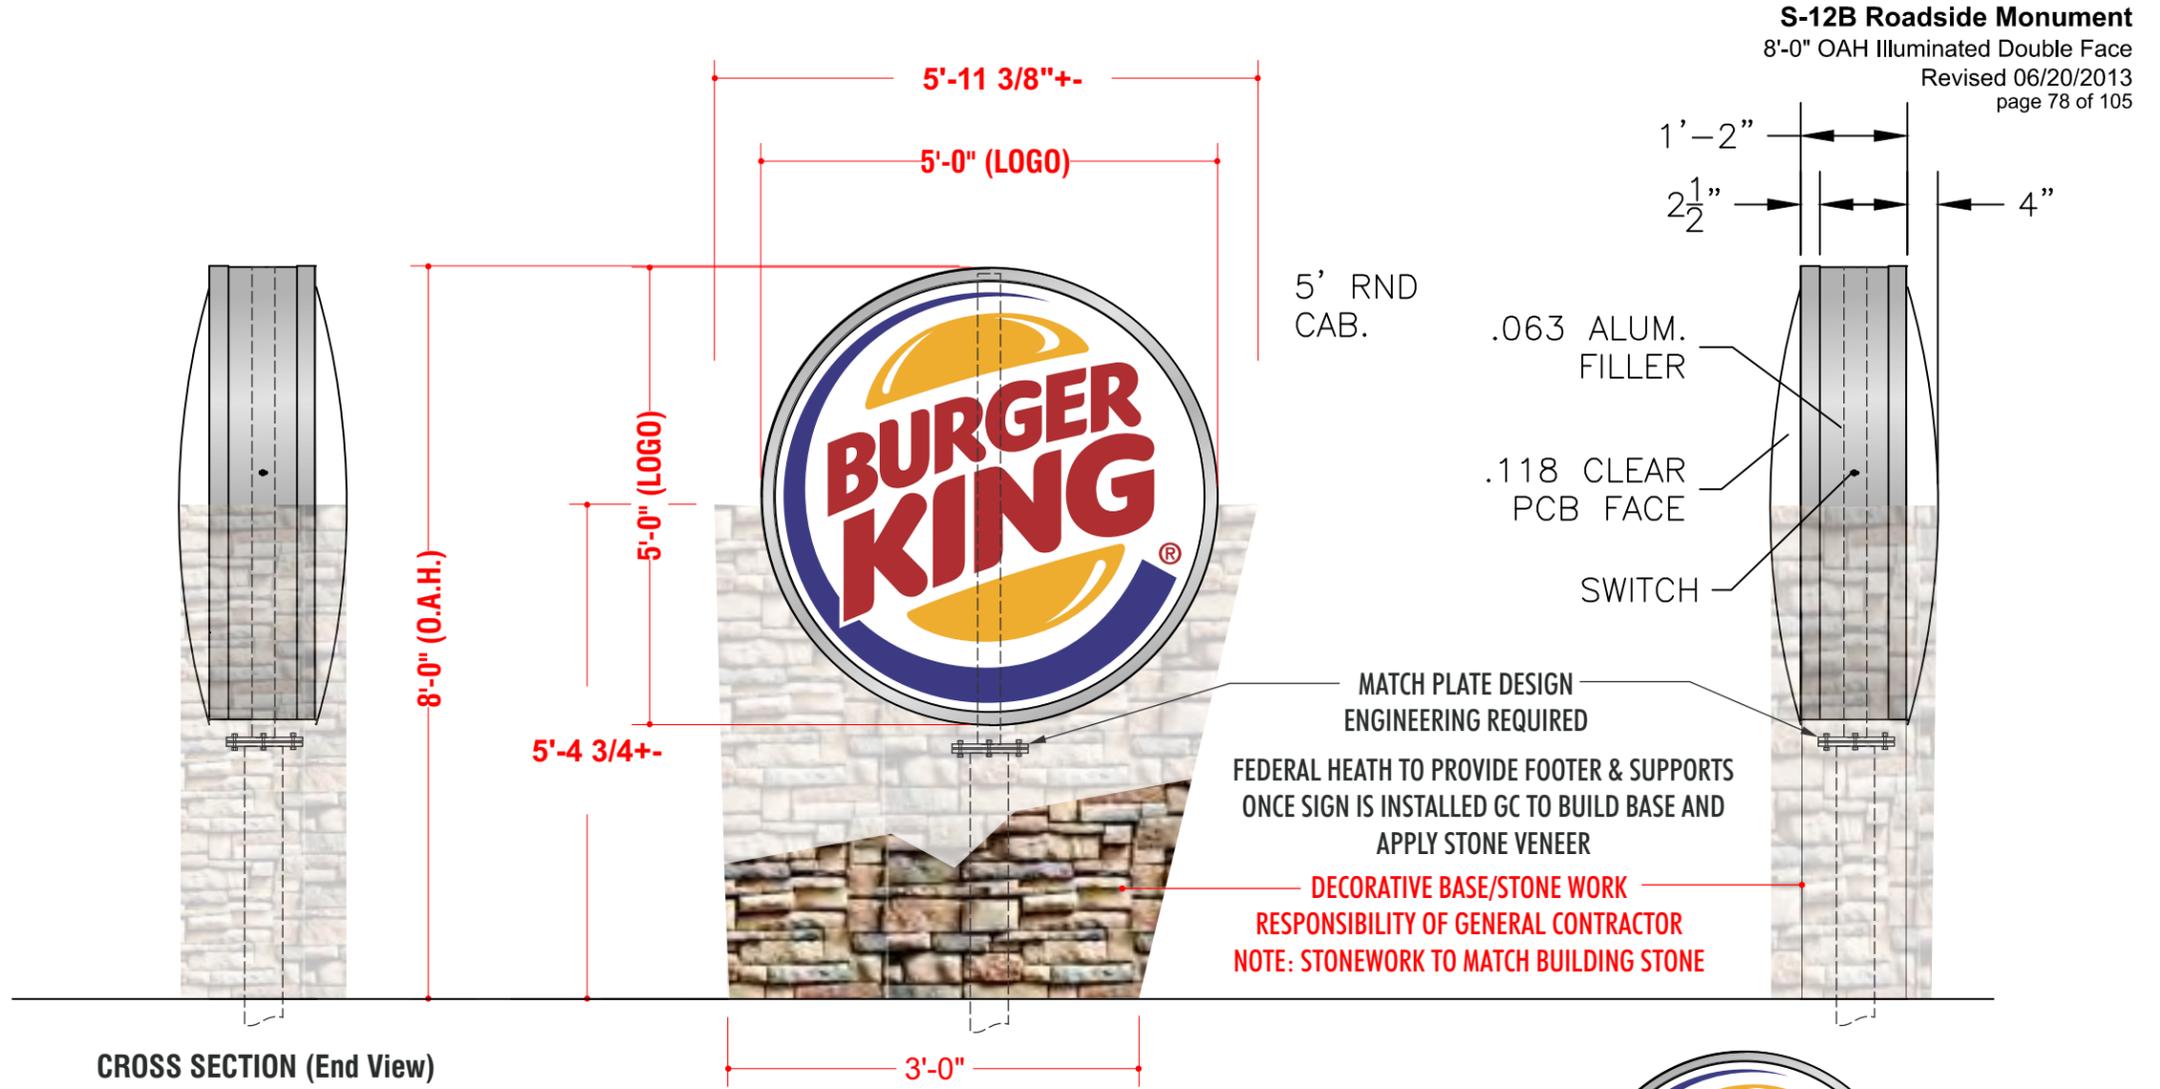

S-12B Roadside Monument
 8'-0" OAH Illuminated Double Face
 Revised 06/20/2013
 page 78 of 105

F **DOUBLE FACED INTERNALLY ILLUMINATED MONUMENT SIGN**
 scale 1/4"=1'-0"

 LOGO
 19.6 SQUARE FEET



***NOTE:**
 INSTALL TOGGLE SWITCH TO OPERATE
 (ON/OFF) IN THE HORIZONTAL POSITION.



OPPOSITE SIDE

FEDERAL HEATH
VISUAL COMMUNICATIONS
 www.FederalHeath.com
 12704 DuPont Circle Tampa, FL 33626
 (813) 855-4415 (800) 284-3284 Fax (813) 854-3037

Manufacturing Facilities:
 Oceanside, CA - Eules, TX - Jacksonville, TX - San Antonio, TX
 Delaware, OH - Racine, WI

Office Locations:
 Oceanside, CA - Las Vegas, NV - Laughlin, AZ
 Idaho Falls, ID - Eules, TX - Jacksonville, TX - San Antonio, TX
 Houston, TX - Corpus Christi, TX - Indianapolis, IN
 Louisville, KY - Knoxville, TN - Grafton, WI - Delaware, OH
 Willowbrook, IL - Tunica, MS - Atlanta, GA
 Tampa, FL - Daytona Beach, FL - Orlando, FL

Building Quality Signage Since 1901

Revisions: **R1 JCR 3/19/20 NEW SITE PLAN & ELEVATIONS**

R2 JCR 3/20/20 ADD SIGN "F"

R3 JK 5/21/20 ADD ADDITIONAL SPECIFICATIONS FOR MONUMENT SIGN (F)

R4 JK 6/05/20 CONFIRM SIGN E IS TO SCALE AND NOTE.

Colors Depicted In This Rendering May Not Match Actual Finished Materials. Refer To Product Samples For Exact Color Match.

Client Approval/Date: _____

Landlord Approval/Date: _____

Account Rep: **Fiona Paul**

Project Manager: **Jeremy Moore**

Drawn By: **Jesthan Delcano/CHC**

UL Underwriters Laboratories Inc. **nec** ELECTRICAL TO USE U.L. LISTED COMPONENTS AND SHALL MEET ALL N.E.C. STANDARDS

ALL ELECTRICAL SIGNS ARE TO COMPLY WITH U.L. 48 AND ARTICLE 600 OF THE N.E.C. STANDARDS, INCLUDING THE PROPER GROUNDING AND BONDING OF ALL SIGNS.

Project / Location: 

Store#: 1366
 317 MAIN ST
 MADISON, NJ 07940

Job Number: 23-55534-10

Date: September 06, 2019

Sheet Number: 16 Of 16

Design Number: **23-55534-10 R4**

This original drawing is provided as part of a planned project and is not to be exhibited, copied or reproduced without the written permission of Federal Heath Sign Company, LLC or its authorized agent. © FHSC