


**AS-BUILT PLAN**

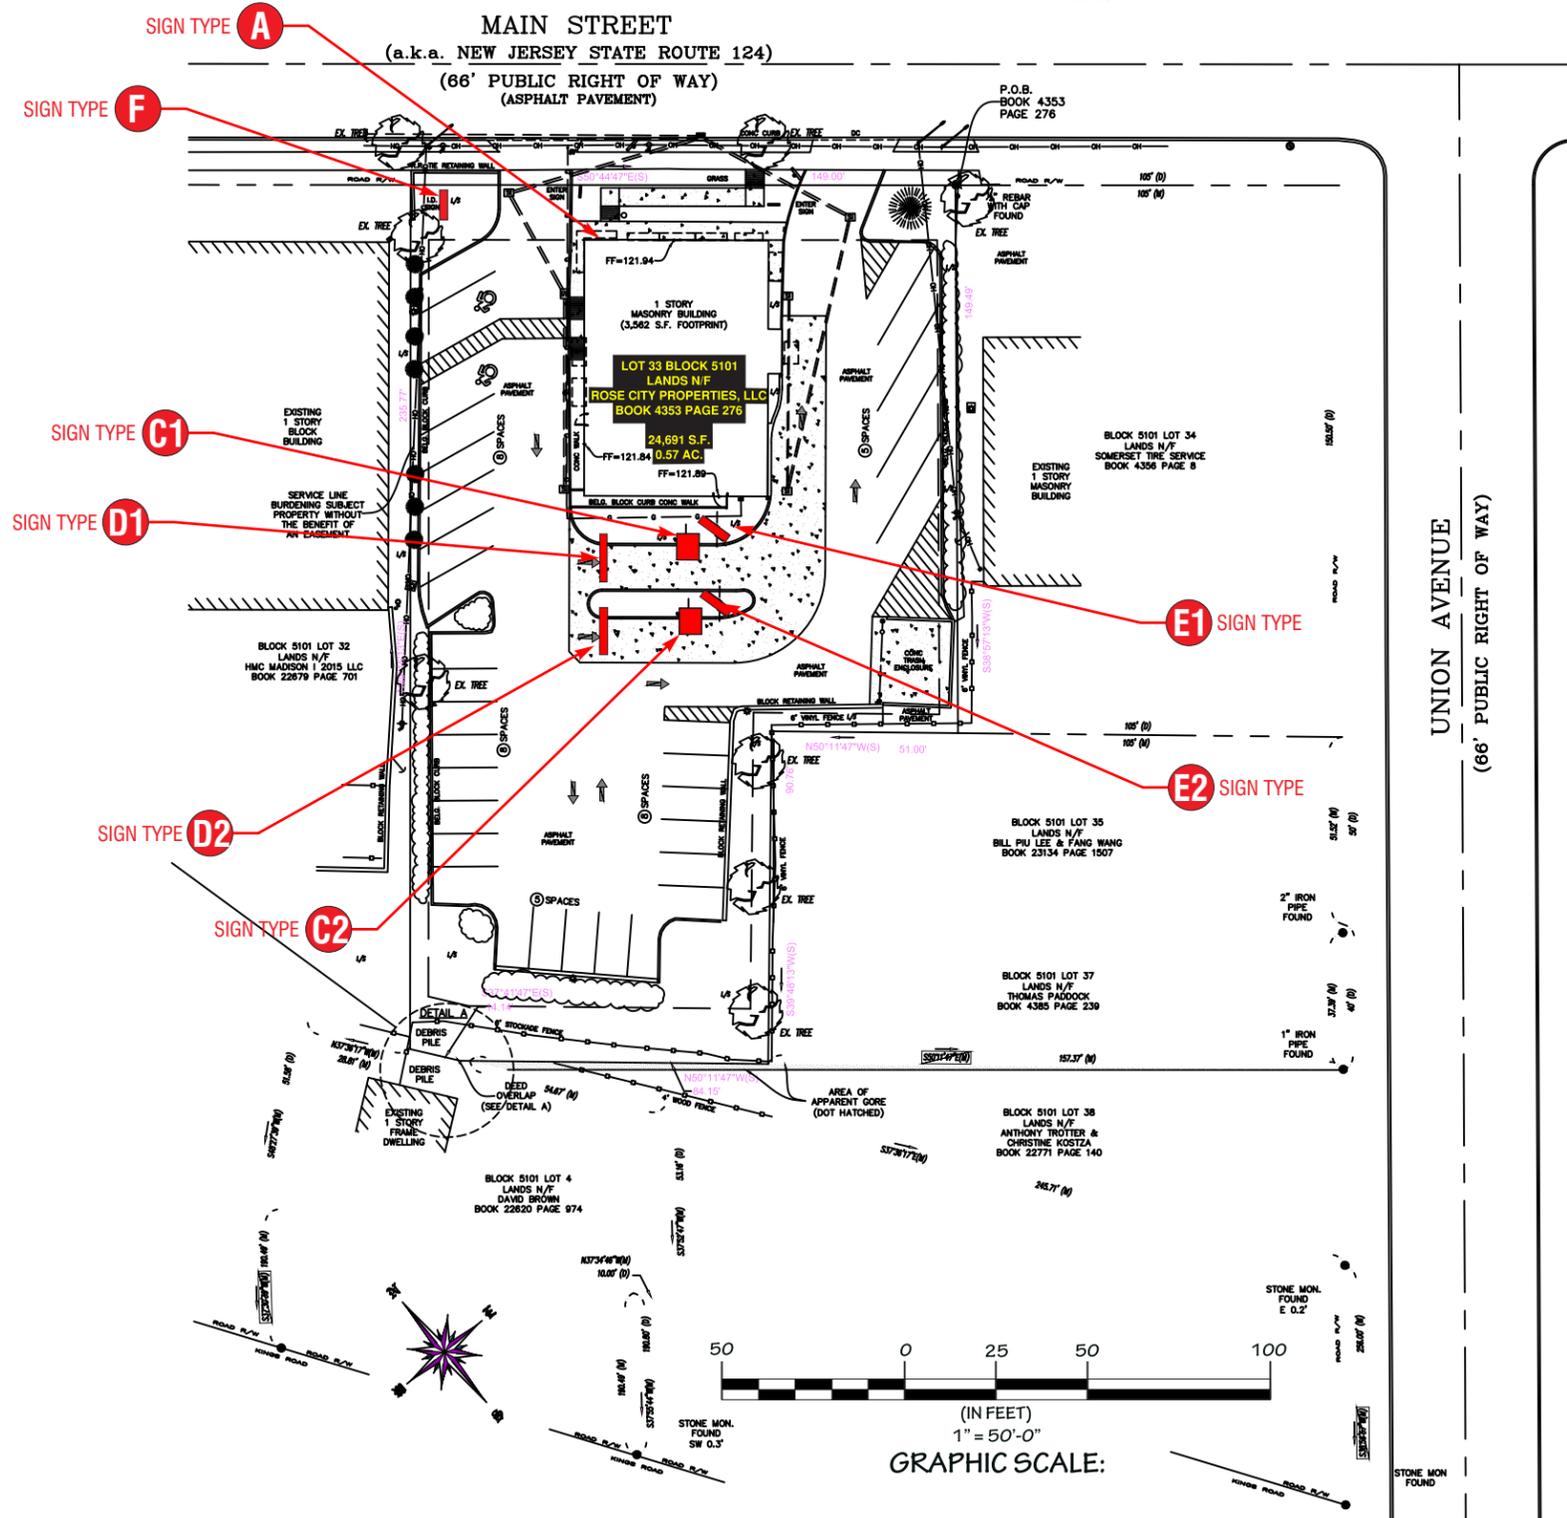

### SIGN SCHEDULE

<b>A</b>	NEW 5'-0" DIA S/F LOGO SIGN <i>(1) ONE REQUIRED</i>
<b>C</b>	ORDER CONFIRMATION UNIT <i>(2) TWO REQUIRED</i>
<b>D</b>	CLEARANCE BAR <i>(2) TWO REQUIRED</i>
<b>E</b>	DIGITAL MENU BOARD <i>(2) TWO REQUIRED</i>
<b>F</b>	D/F MONUMENT SIGN <i>(1) ONE REQUIRED</i>

### WARRANTY NOTICE:

- CERTAIN ELECTRICAL COMPONENTS OF SIGNS WILL FAIL PREMATURELY IF SIGNS ARE NOT SHUT-OFF FOR A PERIOD OF TIME, ONCE, EACH DAY. FOR BEST PERFORMANCE, WE RECOMMEND SIGNS TO BE CONNECTED TO AN AUTOMATIC CONTROLLING DEVICE SUCH AS AN ENERGY MANAGEMENT SYSTEM, TIME CLOCK OR PHOTO CELL THAT WILL AUTOMATICALLY SHUT-OFF THE SIGN FOR A PERIOD OF TIME, EACH DAY. FAILURE TO DO SO WILL CAUSE DAMAGE TO THE ELECTRICAL COMPONENTS OF THE SIGN AND WILL VOID THE WARRANTY.
- SOME DIMMING DEVICES WILL ALSO ADVERSELY AFFECT SIGN ELECTRICAL COMPONENTS, CAUSING FAILURE. ANY DIMMING OF THE SIGN WITHOUT CONSULTATION WITH FEDERAL HEATH SIGN COMPANY WILL VOID THE WARRANTY.

**FEDERAL HEATH**  
VISUAL COMMUNICATIONS  
www.FederalHeath.com  
12704 DuPont Circle Tampa, FL 33626  
(813) 855-4415 (800) 284-3284 Fax (813) 854-3037

Manufacturing Facilities:  
Oceanside, CA - Eules, TX - Jacksonville, TX  
Delaware, OH - Racine, WI

Office Locations:  
Oceanside, CA - Las Vegas, NV - Laughlin, AZ  
Idaho Falls, ID - Eules, TX - Jacksonville, TX - San Antonio, TX  
Houston, TX - Corpus Christi, TX - Indianapolis, IN  
Louisville, KY - Knoxville, TN - Grafton, WI - Delaware, OH  
Willowbrook, IL - Tunica, MS - Atlanta, GA  
Tampa, FL - Daytona Beach, FL - Orlando, FL

**Building Quality Signage Since 1901**

Revisions:  
R1 JCR 3/12/20 NEW SITE PLAN & ELEVATIONS  
R2 JK 3/20/20 ADD SIGN 'F'  
R3 JK 5/21/20 ADD ADDITIONAL SPECIFICATIONS FOR MONUMENT SIGN (F)  
R4 JK 6/05/20 CONFIRM SIGN E IS TO SCALE AND NOTE.  
R5 JG 8/28/20 Update elev. Remove 2 logos, and letters, Update clearance no copy or logo. add dimmer required to wall sign and monument

Colors Depicted In This Rendering May Not Match Actual Finished Materials. Refer To Product Samples For Exact Color Match.

Client Approval/Date: \_\_\_\_\_  
Landlord Approval/Date: \_\_\_\_\_

Account Rep: **Fiona Paul**  
Project Manager: **Jeremy Moore**  
Drawn By: **Jesthan Delcano/CHC**

Underwriters Laboratories Inc. ELECTRICAL TO USE U.L. LISTED COMPONENTS AND SHALL MEET ALL N.E.C. STANDARDS  
ALL ELECTRICAL SIGNS ARE TO COMPLY WITH U.L. 48 AND ARTICLE 600 OF THE N.E.C. STANDARDS, INCLUDING THE PROPER GROUNDING AND BONDING OF ALL SIGNS.

Project / Location: **Store#: 1366**  
**317 MAIN ST**  
**MADISON, NJ 07940**


Job Number: **23-55534-10**  
Date: **September 06, 2019**  
Sheet Number: **1** Of **14**  
Design Number: **23-55534-10 R6**

This original drawing is provided as part of a planned project and is not to be exhibited, copied or reproduced without the written permission of Federal Heath Sign Company, LLC or its authorized agent. © FHSC



**DINING ROOM ELEVATION**

SCALE: 1/8" = 1'-0"

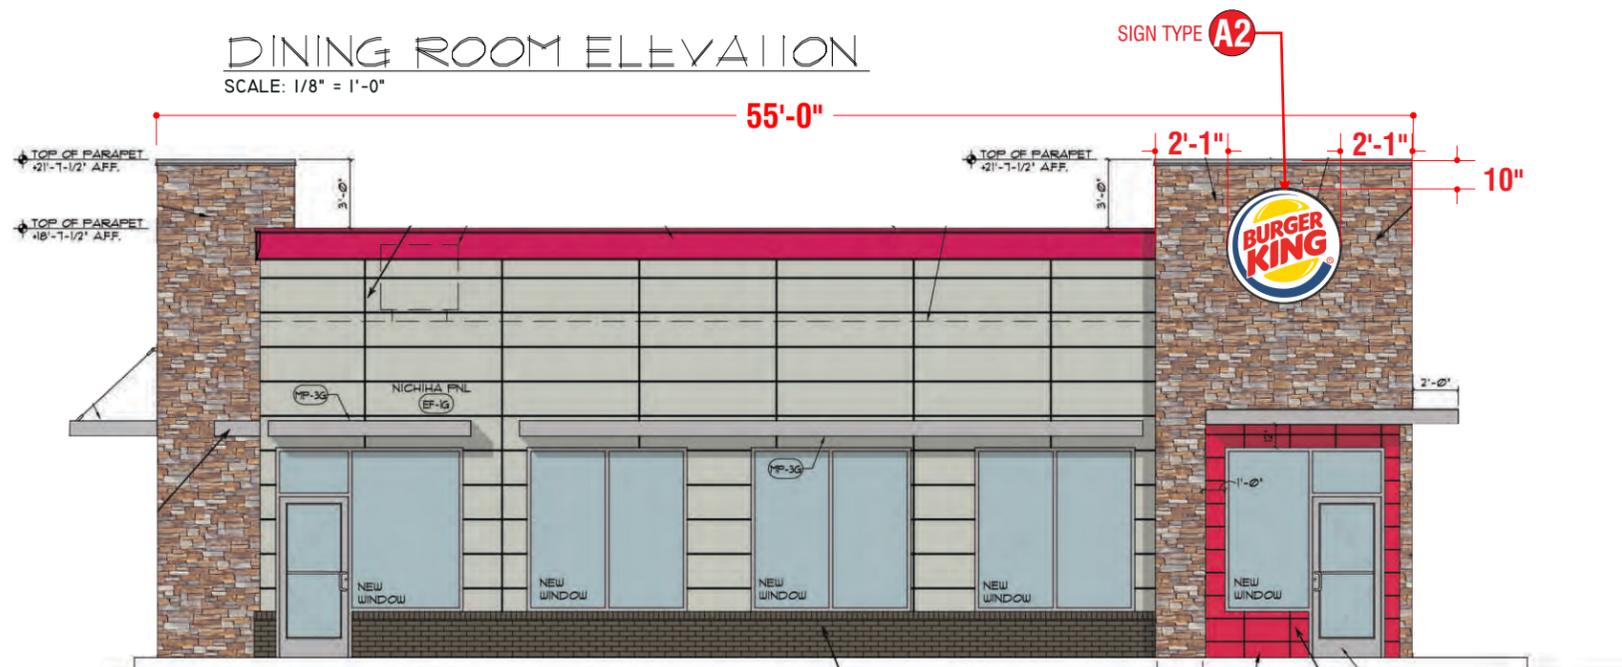


**FRONT ELEVATION**

SCALE: 1/8" = 1'-0"


**SIGN SCHEDULE**

- A** NEW 5'-0" DIA S/F LOGO SIGN  
*(1) ONE REQUIRED*
- C** ORDER CONFIRMATION UNIT  
*(2) TWO REQUIRED*
- D** CLEARANCE BAR  
*(2) TWO REQUIRED*
- E** DIGITAL MENU BOARD  
*(2) TWO REQUIRED*
- F** D/F MONUMENT SIGN  
*(1) ONE REQUIRED*

**NOTE: BUILDING CANOPIES BY OTHERS**

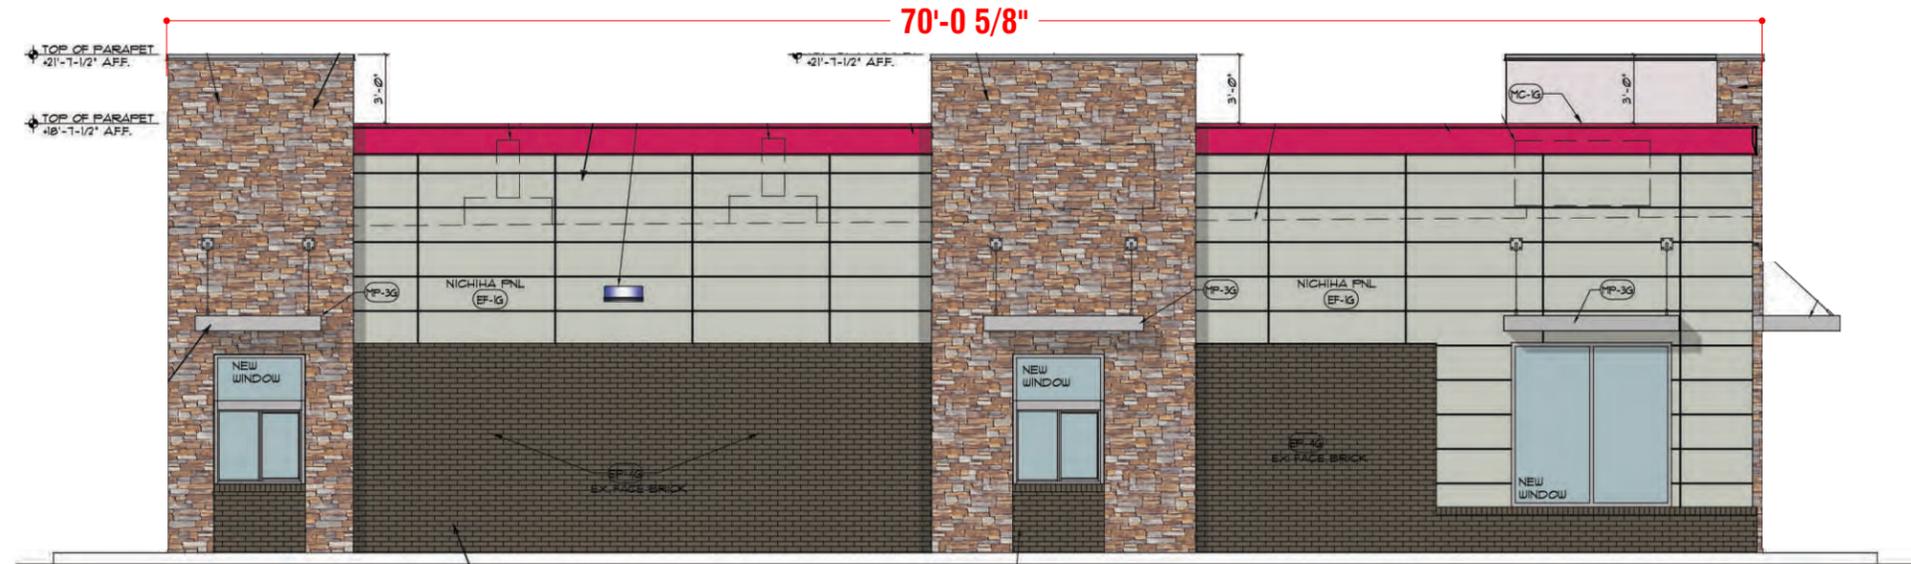

DRIVE-THRU ELEVATION  
SCALE: 1/8" = 1'-0"

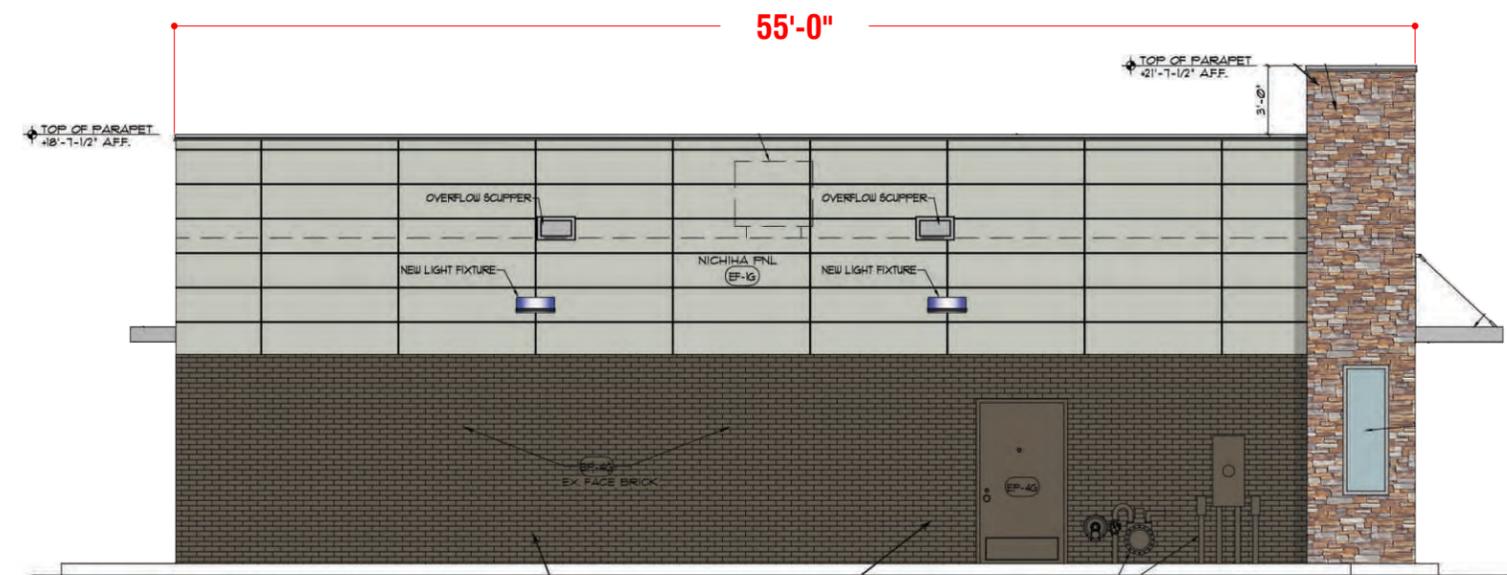

REAR ELEVATION  
SCALE: 1/8" = 1'-0"

<b>SIGN SCHEDULE</b>	
<b>A</b>	NEW 5'-0" DIA S/F LOGO SIGN <i>(1) ONE REQUIRED</i>
<b>C</b>	ORDER CONFIRMATION UNIT <i>(2) TWO REQUIRED</i>
<b>D</b>	CLEARANCE BAR <i>(2) TWO REQUIRED</i>
<b>E</b>	DIGITAL MENU BOARD <i>(2) TWO REQUIRED</i>
<b>F</b>	D/F MONUMENT SIGN <i>(1) ONE REQUIRED</i>

**NOTE: BUILDING CANOPIES BY OTHERS**

**FEDERAL HEATH**  
VISUAL COMMUNICATIONS  
www.FederalHeath.com  
12704 DuPont Circle Tampa, FL 33626  
(813) 855-4415 (800) 284-3284 Fax (813) 854-3037

Manufacturing Facilities:  
Oceanside, CA - Eules, TX - Jacksonville, TX  
Delaware, OH - Racine, WI  
Office Locations:  
Oceanside, CA - Las Vegas, NV - Laughlin, AZ  
Idaho Falls, ID - Eules, TX - Jacksonville, TX - San Antonio, TX  
Houston, TX - Corpus Christi, TX - Indianapolis, IN  
Louisville, KY - Knoxville, TN - Grafton, WI - Delaware, OH  
Willowbrook, IL - Tunica, MS - Atlanta, GA  
Tampa, FL - Daytona Beach, FL - Orlando, FL

Revisions:  
R1 JCR 3/19/20 NEW SITE PLAN & ELEVATIONS  
R2 JCR 3/20/20 ADD SIGN F  
R3 JK 5/21/20 ADD ADDITIONAL SPECIFICATIONS FOR MONUMENT SIGN (F)  
R4 JK 6/05/20 CONFIRM SIGN E IS TO SCALE AND NOTE.  
R5 JG 8/28/20 Update elev. Remove 2 logos, and letters, Update clearance no copy or logo. add dimmer required to wall sign and monument  
R6 JG 8/31/20 Update CLEARANCE COPY  
Colors Depicted In This Rendering May Not Match Actual Finished Materials. Refer To Product Samples For Exact Color Match.  
Client Approval/Date: \_\_\_\_\_  
Landlord Approval/Date: \_\_\_\_\_

Account Rep: Fiona Paul  
Project Manager: Jeremy Moore  
Drawn By: Jeshan Delcano/CHC  
UL Underwriters Laboratories Inc. ncc  
ELECTRICAL TO USE U.L. LISTED COMPONENTS AND SHALL MEET ALL N.E.C. STANDARDS  
ALL ELECTRICAL SIGNS ARE TO COMPLY WITH U.L. 48 AND ARTICLE 600 OF THE N.E.C. STANDARDS, INCLUDING THE PROPER GROUNDING AND BONDING OF ALL SIGNS.

Project / Location:  
  
Store #: 1366  
317 MAIN ST  
MADISON, NJ 07940


Job Number: 23-55534-10  
Date: September 06, 2019  
Sheet Number: 3 Of 14  
Design Number: 23-55534-10 R6

This original drawing is provided as part of a planned project and is not to be exhibited, copied or reproduced without the written permission of Federal Heath Sign Company, LLC or its authorized agent. © FHSC

**NON-STANDARD**


DIMMER SWITCH REQUIRED

FILE NAME: BK1060CS.20\_60 DIA SF GE 24V LED CABINET

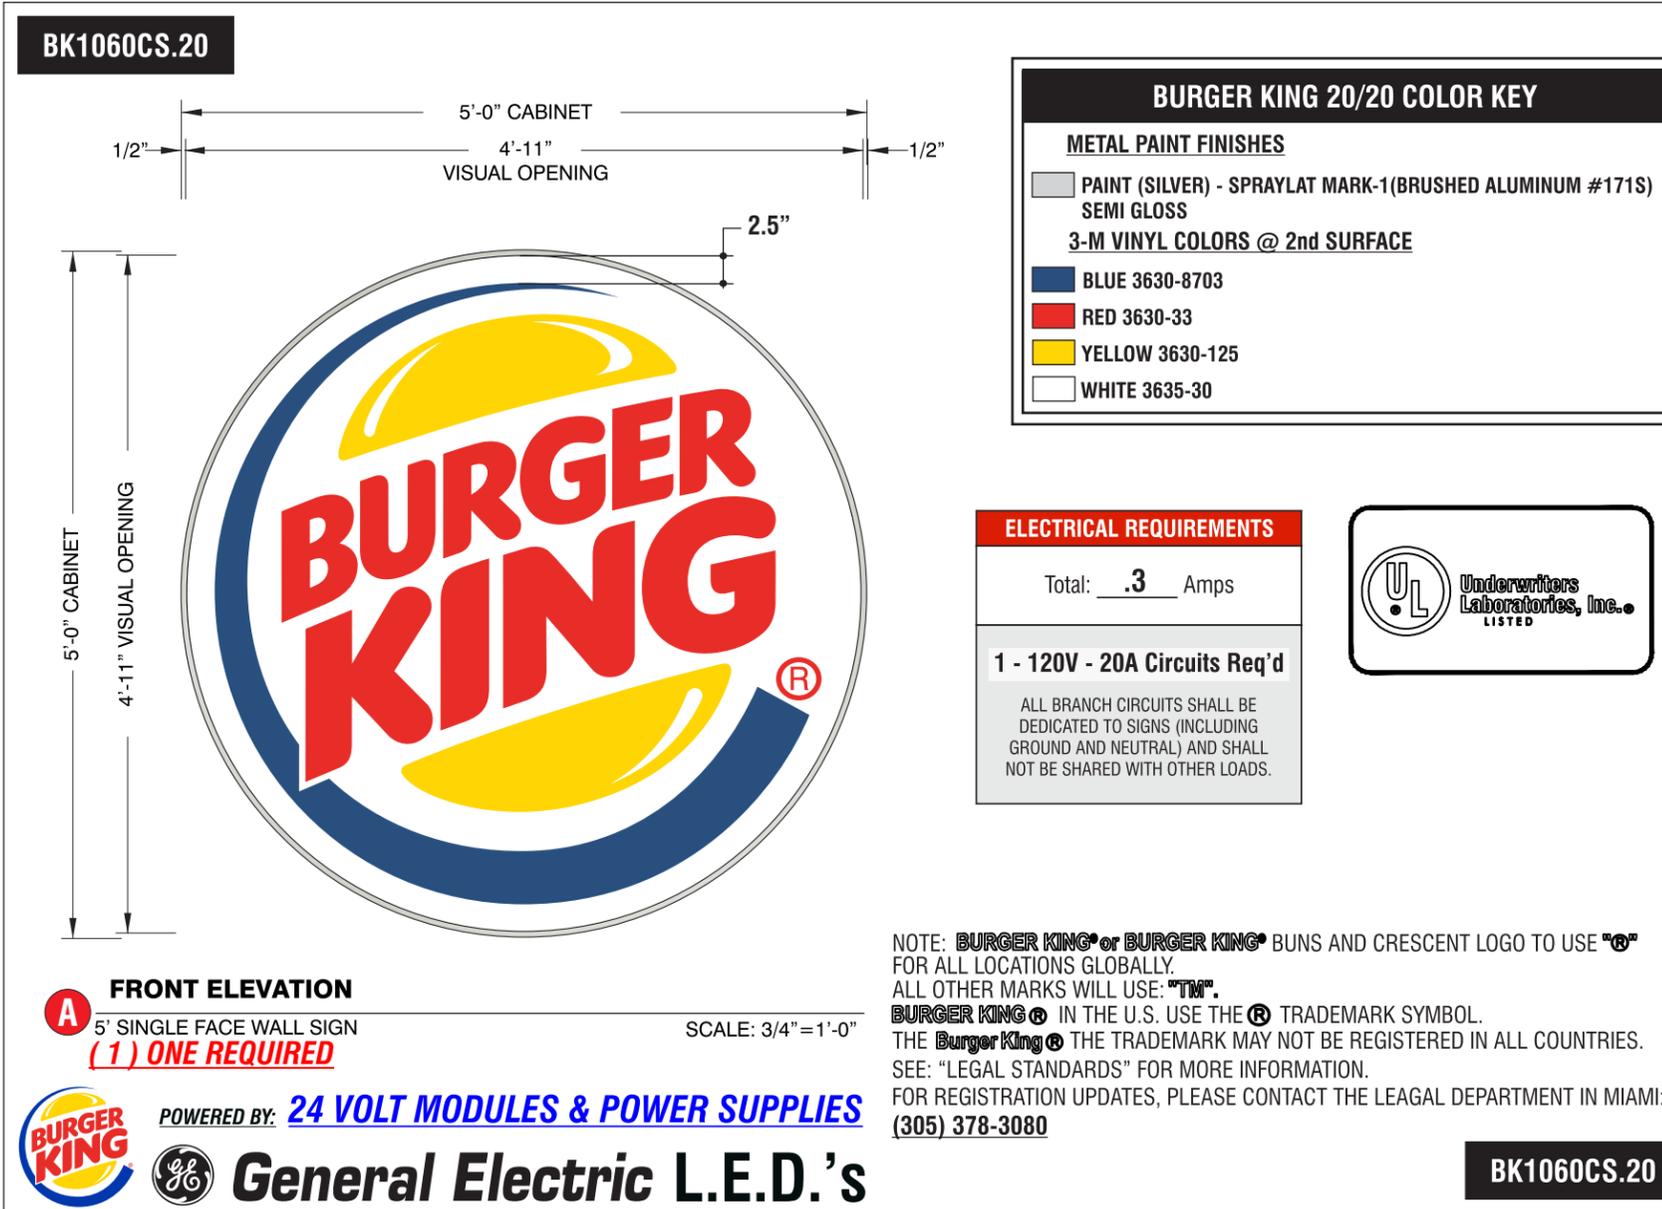

FILE NAME: BK1060CS.20\_60 DIA SF GE 24V LED CABINET

BK1060CS.20

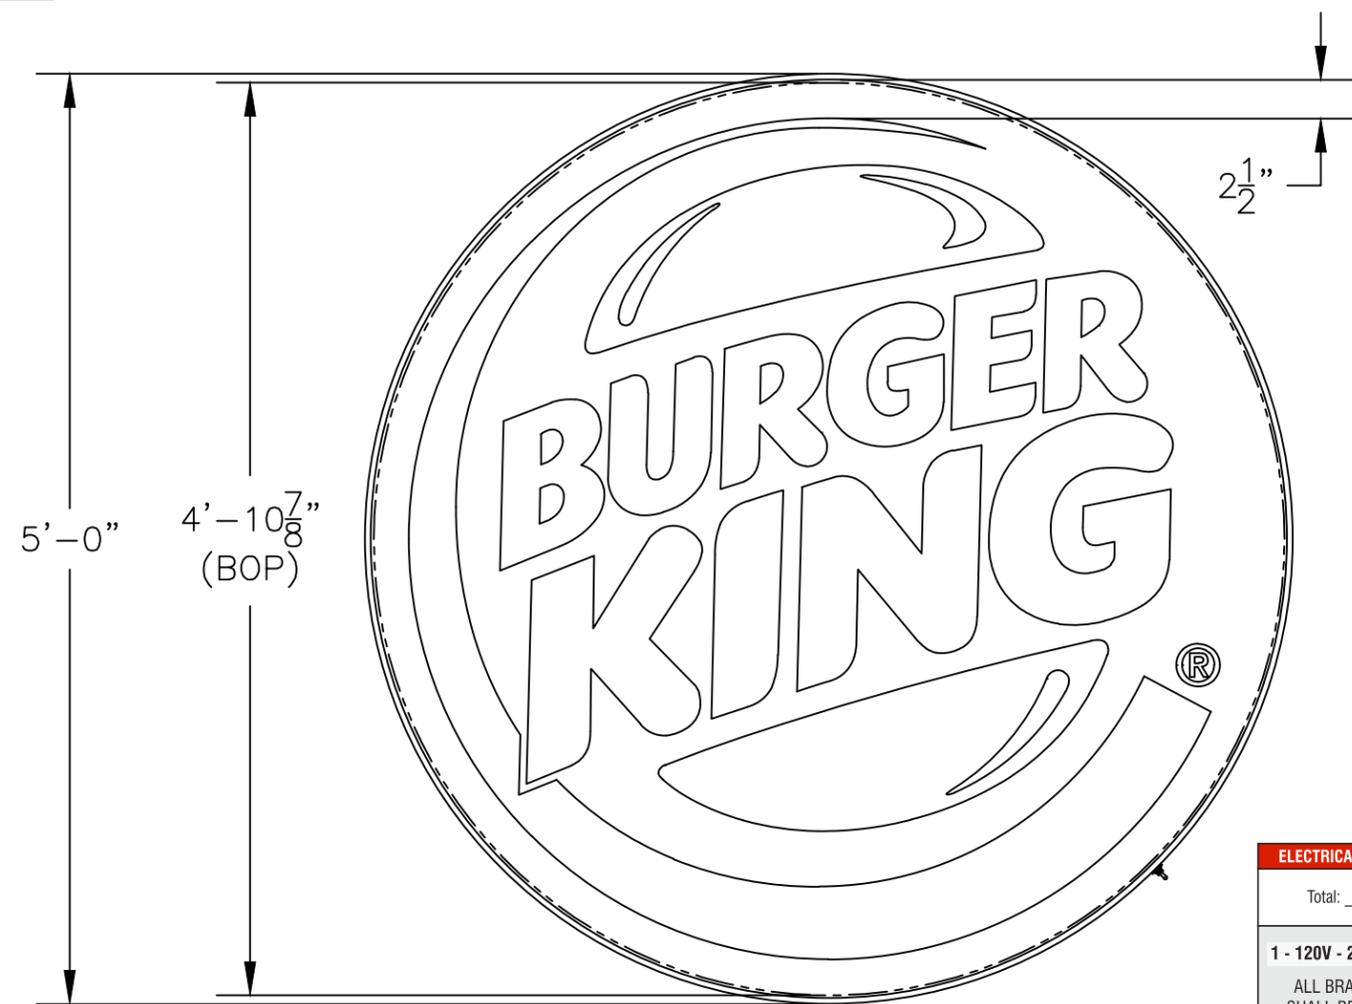


FRONT ELEVATION  
SCALE: 1" = 1'-0"

LOGO  
19.6 SQUARE FEET

- FORMED (VOID) .118 CLEAR FACE
- 3/8" Ø THREADED ROD w/ REQ'D BLOCKING
- WHITE GE 24V TETRA MAX LED (7100K)
- 24V GE POWER SUPPLY
- 3.5"x.040 ALUM. RETURN CONNECTOR/ CONDUIT
- SWITCH
- .090 ALUM. BACK
- 1/2"x1 1/2" DEAD SOFT RETAINER
- WEEP HOLE w/LIGHT BAFFLE

ELECTRICAL REQUIREMENTS	
Total:	.3 Amps
1 - 120V - 20A Circuits Req'd	
ALL BRANCH CIRCUITS SHALL BE DEDICATED TO	

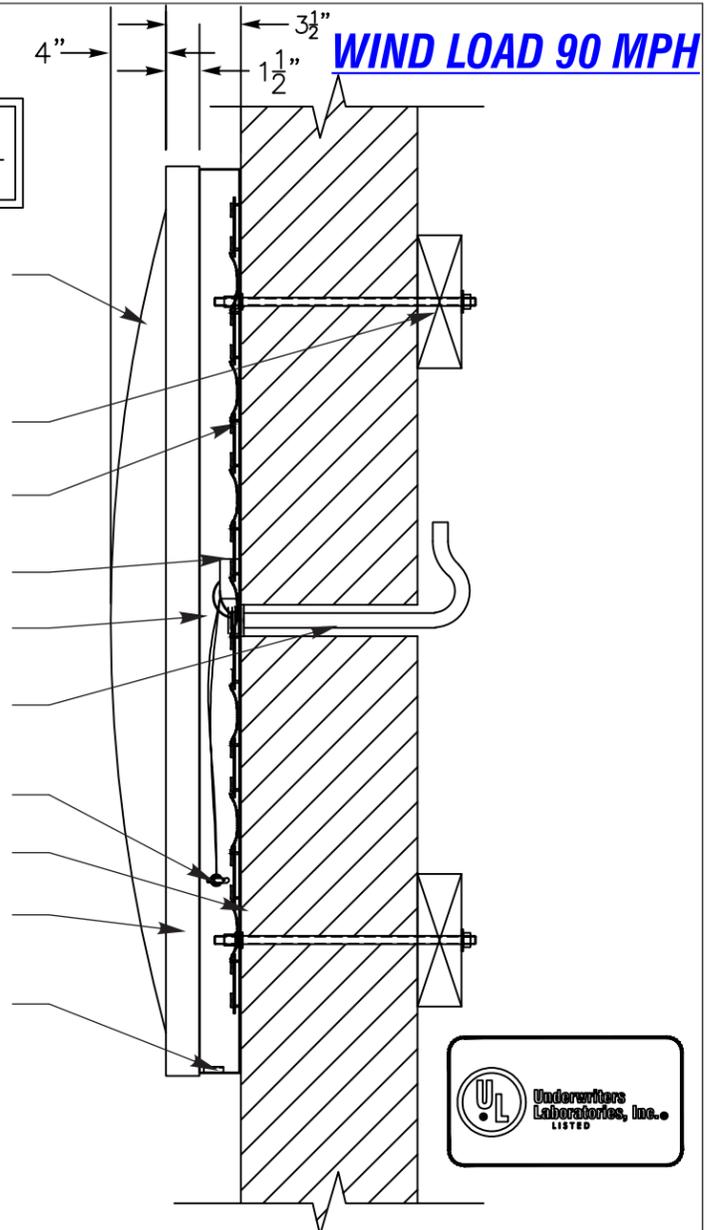

SIDE VIEW  
SCALE: 1" = 1'-0"

**COLOR NOTES:**

- BACKS: .090 ALUM. w/ WHITE FINISH
- RETURNS/ RETAINER: 3.5"x.040 ALUM. (STAPLED & CAULKED)
- PRE-FINISHED BK SILVER/ WHITE
- FACE: FORMED (VOID) .118 CLEAR PCB
- BUN LOGO: 3M 3630-125 YELLOW
- ACCENT RING: 3M 3630-8703 BLUE
- COPY/ RTM: 3M 3630-33 RED
- BKG'D/ BUN ACCENT: 3M 3635-30 WHITE DIFFUSER
- ILLUMINATION: 24V GE TETRA MAX 7100K LED
- \*\*\*VINYL TO BE APPLIED 2nd SURFACE\*\*\*

**ELECTRICAL NOTE**—Actual # of circuits to be determined by a Licensed Electrical Contractor.  
 TOTAL AMPS: 0.3  
 # OF CKTS: 1 @ 20 AMP(RECOMMENDED)  
 VOLTS: 120 or 277 (MULTI SOURCE) P.S.  
 ALL SIGNAGE WILL BE (U.L.) LISTED, (U.L.) 2161 COMPLIANT AND CARRY (U.L.) LABELS.



POWERED BY: **24 VOLT MODULES & POWER SUPPLIES**

**General Electric L.E.D.'s**



\*NOTE:  
INSTALL TOGGLE SWITCH TO OPERATE (ON/OFF) IN THE HORIZONTAL POSITION.

FILE NAME: BK1060CS.20\_60 DIA SF GE 24V LED CABINET

**BK1060CS.20**

**FEDERAL HEATH**  
 VISUAL COMMUNICATIONS  
 www.FederalHeath.com  
 12704 DuPont Circle Tampa, FL 33626  
 (813) 855-4415 (800) 284-3284 Fax (813) 854-3037

Manufacturing Facilities:  
 Oceanside, CA - Euless, TX - Jacksonville, TX  
 Delaware, OH - Racine, WI  
 Office Locations:  
 Oceanside, CA - Las Vegas, NV - Laughlin, AZ  
 Idaho Falls, ID - Euless, TX - Jacksonville, TX - San Antonio, TX  
 Houston, TX - Corpus Christi, TX - Indianapolis, IN  
 Louisville, KY - Knoxville, TN - Grafton, WI - Delaware, OH  
 Willowbrook, IL - Tunica, MS - Atlanta, GA  
 Tampa, FL - Daytona Beach, FL - Orlando, FL

Revisions:  
 R1 JCR 3/19/20 NEW SITE PLAN & ELEVATIONS  
 R2 JCR 3/20/20 ADD SIGN F  
 R3 JK 5/21/20 ADD ADDITIONAL SPECIFICATIONS FOR MONUMENT SIGN (F)  
 R4 JK 6/05/20 CONFIRM SIGN E IS TO SCALE AND NOTE.  
 R5 JG 8/28/20 Update elev. Remove 2 logos, and letters, Update clearance no copy or logo. add dimmer required to wall sign and monument  
 R6 JG 8/31/20 Update CLEARANCE COPY

Colors Depicted In This Rendering May Not Match Actual Finished Materials. Refer To Product Samples For Exact Color Match.

Client Approval/Date: \_\_\_\_\_  
 Landlord Approval/Date: \_\_\_\_\_

Account Rep: **Fiona Paul**  
 Project Manager: **Jeremy Moore**  
 Drawn By: **Jesthan Delcano/CHC**

**UL** Underwriters Laboratories Inc. **nec** ELECTRICAL TO USE U.L. LISTED COMPONENTS AND SHALL MEET ALL N.E.C. STANDARDS  
 ALL ELECTRICAL SIGNS ARE TO COMPLY WITH U.L. 48 AND ARTICLE 600 OF THE N.E.C. STANDARDS, INCLUDING THE PROPER GROUNDING AND BONDING OF ALL SIGNS.

Project / Location: **BURGER KING**  
 Store #: 1366  
 317 MAIN ST  
 MADISON, NJ 07940


Job Number: **23-55534-10**  
 Date: **September 06, 2019**  
 Sheet Number: **5** Of **14**  
 Design Number: **23-55534-10 R6**

This original drawing is provided as part of a planned project and is not to be exhibited, copied or reproduced without the written permission of Federal Heath Sign Company, LLC or its authorized agent. © FHSC

BK1060CS.20

**LOW WIND LOAD**  
**WIND LOAD 90 MPH**

1/2"x1 1/2" DEAD SOFT ALUM. RETAINER  
ATTACHED WITH (2)  
# 8 S.M. SCREWS @ EACH  
SIDE OF THE SEAM, THEN @  
14" CENTERS ALL AROUND  
PERIMETER OF RETAINER

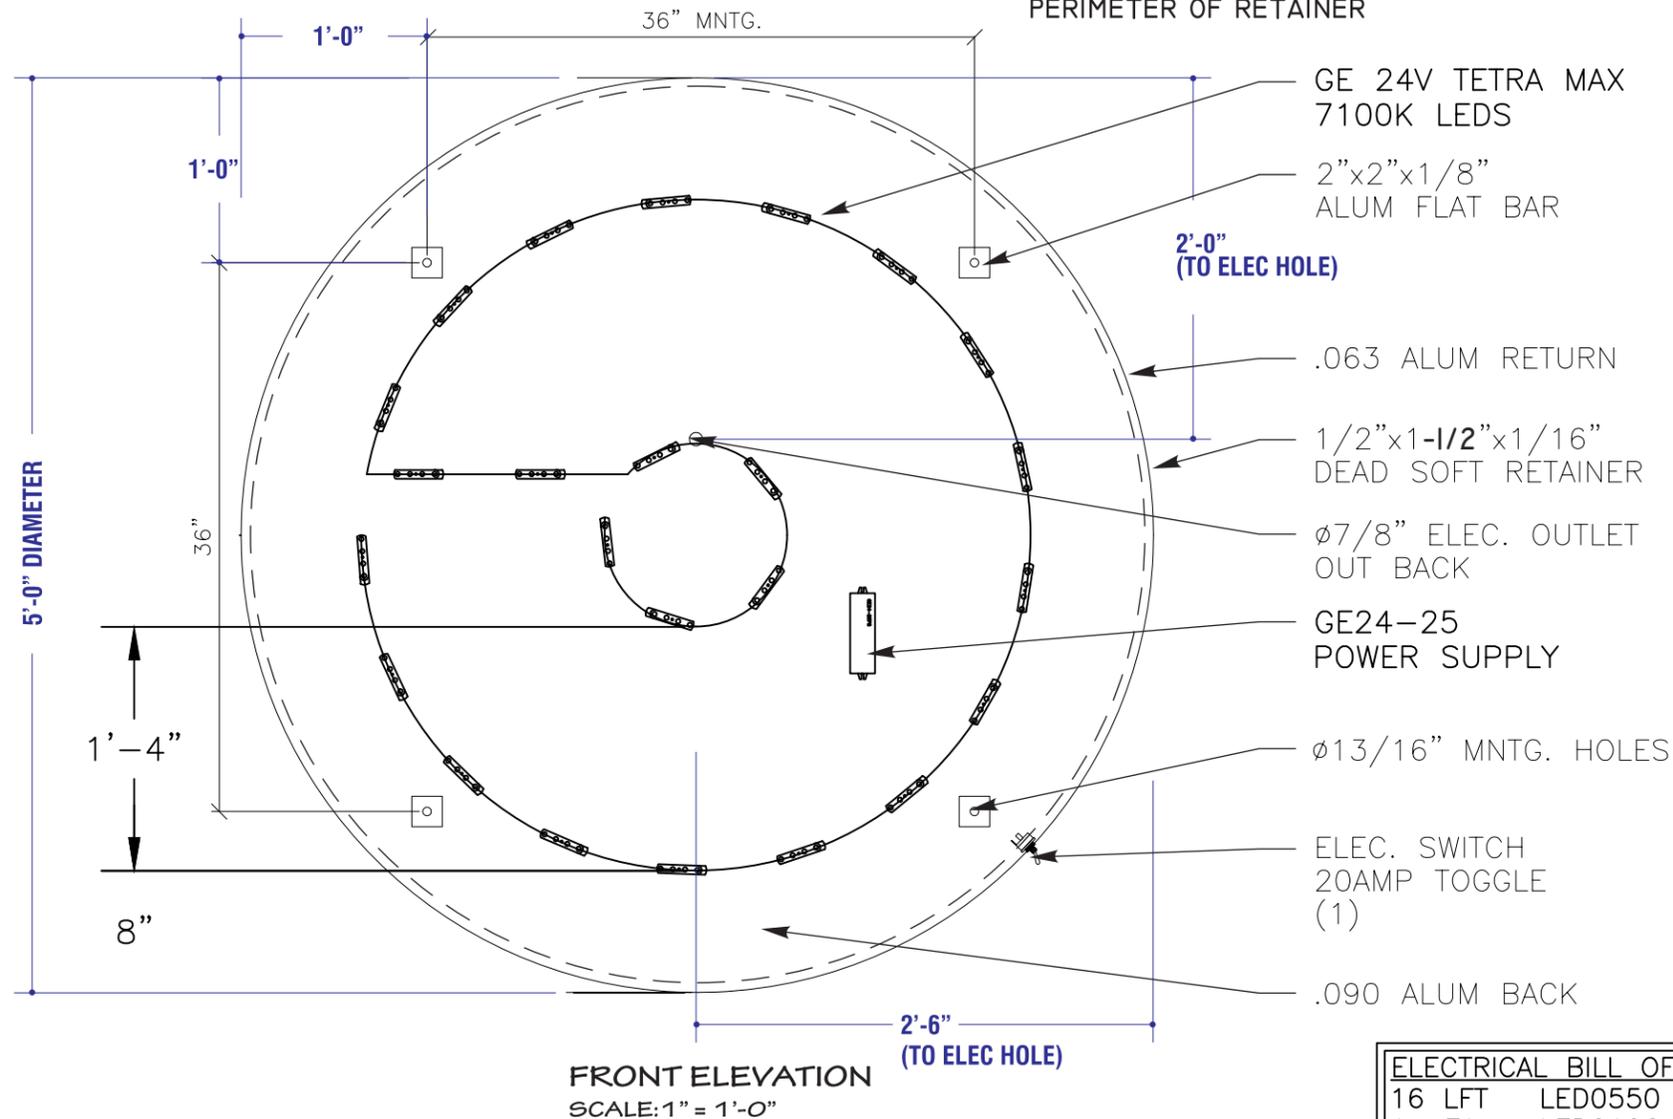

ELECTRICAL REQUIREMENTS	
Total:	.3 Amps
<b>1 - 120V - 20A Circuits Req'd</b>	
ALL BRANCH CIRCUITS SHALL BE DEDICATED TO SIGNS (INCLUDING GROUND AND NEUTRAL) AND SHALL NOT BE SHARED WITH OTHER LOADS.	

ELECTRICAL BILL OF MATERIAL:		
16 LFT	LED0550	TETRA MAX 24V 7100K LEDS
1 EA	LED0106	GEPS24-25 PS
1 EA	ELT0041	DISCONNECT SWITCH
4 LFT	ELT0089	1/2" CARFLEX
1 EA	ELT0092	SEALTITE CONNECTOR



POWERED BY: **24 VOLT MODULES & POWER SUPPLIES**



**General Electric L.E.D.'s**

FILE NAME: BK1060CS.20\_60 DIA SF GE 24V LED CABINET

**BK1060CS.20**



**VISUAL COMMUNICATIONS**

www.FederalHeath.com

12704 DuPont Circle Tampa, FL 33626

(813) 855-4415 (800) 284-3284 Fax (813) 854-3037

Building Quality Signage Since 1901

Revisions:

R1 JCR 3/19/20 NEW SITE PLAN & ELEVATIONS  
R2 JCR 3/20/20 ADD SIGN "F"  
R3 JK 5/21/20 ADD ADDITIONAL SPECIFICATIONS FOR MONUMENT SIGN (F)  
R4 JK 6/05/20 CONFIRM SIGN E IS TO SCALE AND NOTE.

R5 JG 8/28/20 Update elev. Remove 2 logos, and letters, Update clearance no copy or logo. add dimmer required to wall sign and monument

Colors Depicted In This Rendering May Not Match Actual Finished Materials. Refer To Product Samples For Exact Color Match.

Client Approval/Date: \_\_\_\_\_

 
Landlord Approval/Date: \_\_\_\_\_

R6 JG 8/31/20 Update CLEARANCE COPY

Account Rep: **Fiona Paul**

Project Manager: **Jeremy Moore**

Drawn By: **Jesthan Delcano/CHC**



ELECTRICAL TO USE U.L. LISTED COMPONENTS AND SHALL MEET ALL N.E.C. STANDARDS

ALL ELECTRICAL SIGNS ARE TO COMPLY WITH U.L. 48 AND ARTICLE 600 OF THE N.E.C. STANDARDS, INCLUDING THE PROPER GROUNDING AND BONDING OF ALL SIGNS.

Project / Location:



Store#: 1366  
317 MAIN ST  
MADISON, NJ 07940

Job Number: **23-55534-10**

Date: **September 06, 2019**

Sheet Number: **6** Of **14**

Design Number: **23-55534-10 R6**

This original drawing is provided as part of a planned project and is not to be exhibited, copied or reproduced without the written permission of Federal Heath Sign Company, LLC or its authorized agent. © FHSC

**OCU (WOOD GRAIN)  
(W/O VIDEO DISPLAY)  
PART#  
BK9010FM.OCUWGND**

**STEEL SUPPORT NOTE:**

STEEL CONTINGENT ON ENGINEERS SPEC. AND WIND LOAD REQUIREMENTS.  
STEEL BASE PLATE w/STEEL ANCHOR BOLTS AND CONCRETE FOUNDATION.  
ANCHOR BOLT OR DIRECT BURIAL FOUNDATION SHOULD BE PROVIDED BY  
ENGINEER FOR LOCAL WIND LOAD REQUIREMENTS.




**COLOR NOTE:**

REVEAL/SUPPORT STEEL: PAINT BURGER KING RED  
CANOPY TOP: PAINT BURGER KING SILVER  
CABINET FACE: W/3M DI-NOC WOODGRAIN VINYL PART # 1140EX  
OCU CABINET FACE: PAINT BURGER KING SILVER  
CABINET BACK: WOODGRAIN VINYL PART # 1140EX  
OCU BOLT KIT: PAINT BURGER KING RED



FOUNDATIONS AND STRUCTURAL ELEMENTS SHALL BE CALCULATED IN COMPLIANCE WITH APPLICABLE CODES.

**TAKE TO NOTE:**  
**OCU (WOOD GRAIN)  
(W/O VIDEO DISPLAY)  
PART# BK9010FM.OCUWGND  
(SPECIAL BUILD)**

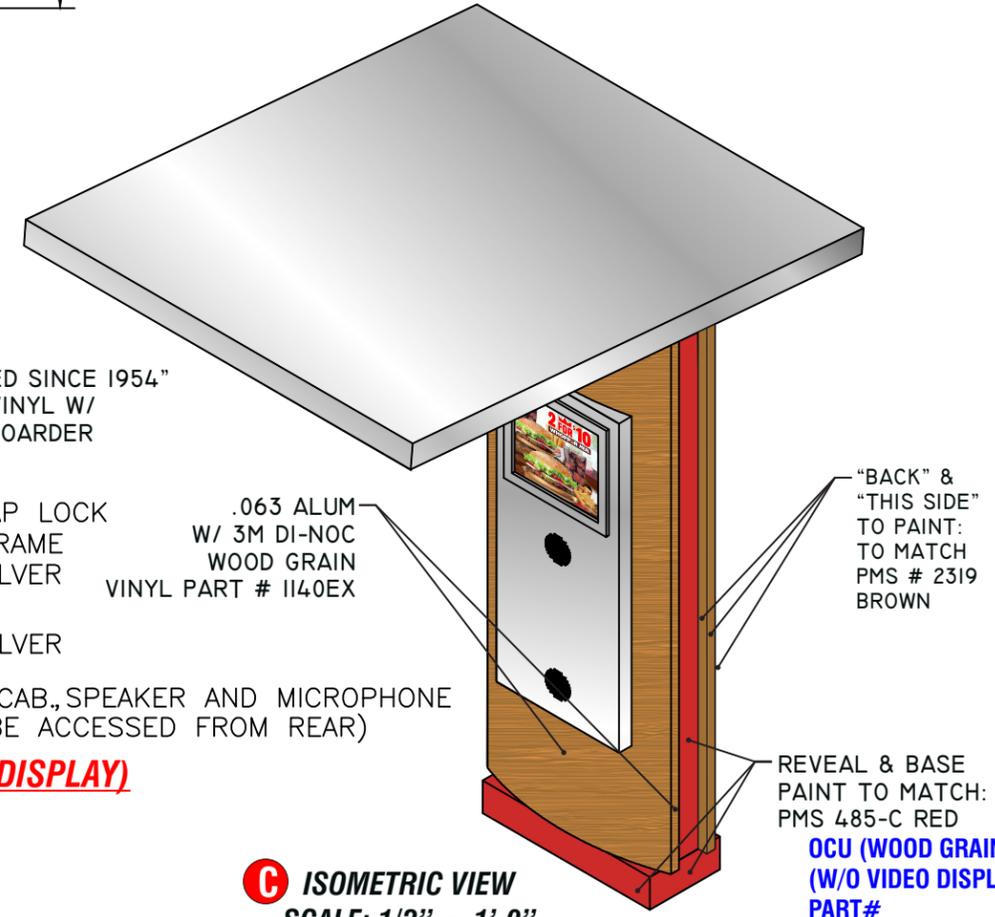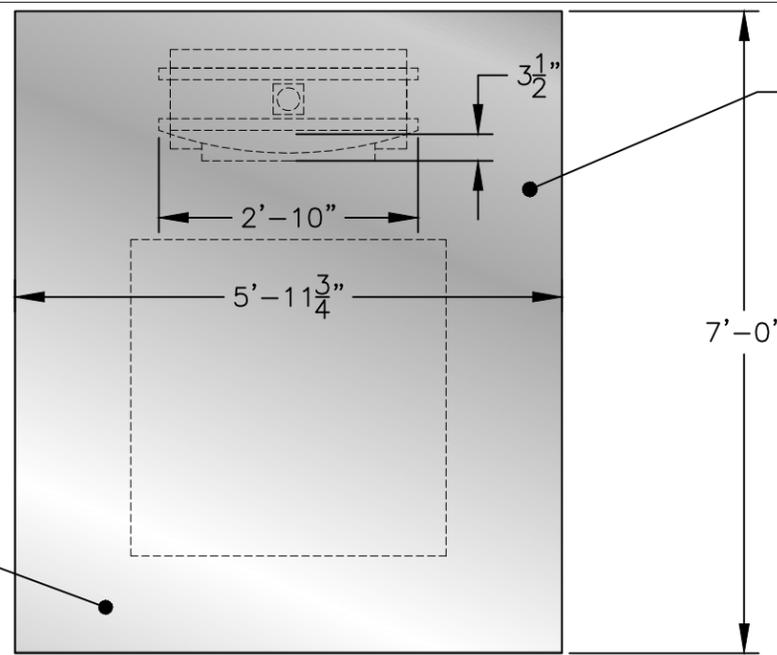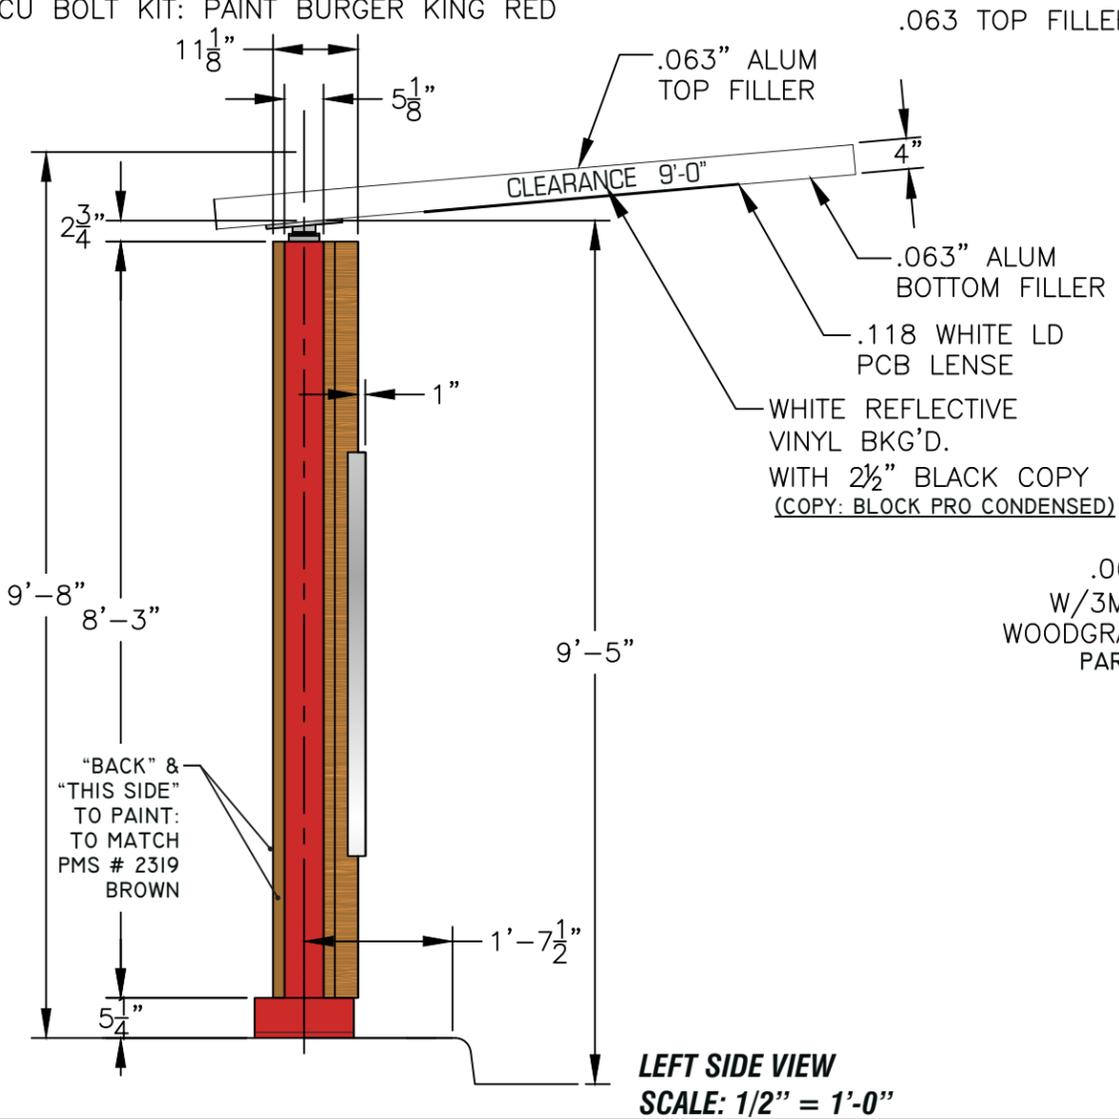

**ISOMETRIC VIEW  
SCALE: 1/2" = 1'-0"  
TWO (2) REQ**

FILE NAME: 2019\_BK 9010FM.OCUWGND(NO VIDEO DISPLAY)

www.FederalHeath.com  
12704 DuPont Circle Tampa, FL 33626  
(813) 855-4415 (800) 284-3284 Fax (813) 854-3037

Manufacturing Facilities:  
Oceanside, CA - Eules, TX - Jacksonville, TX  
Delaware, OH - Racine, WI

Office Locations:  
Oceanside, CA - Las Vegas, NV - Laughlin, AZ  
Idaho Falls, ID - Eules, TX - Jacksonville, TX - San Antonio, TX  
Houston, TX - Corpus Christi, TX - Indianapolis, IN  
Louisville, KY - Knoxville, TN - Grafton, WI - Delaware, OH  
Willowbrook, IL - Tunica, MS - Atlanta, GA  
Tampa, FL - Daytona Beach, FL - Orlando, FL

Revisions:  
R1 JK 3/19/20 NEW SITE PLAN & ELEVATIONS  
R2 JK 3/20/20 ADD SIGN F  
R3 JK 5/21/20 ADD ADDITIONAL SPECIFICATIONS FOR MONUMENT SIGN (F)  
R4 JK 6/05/20 CONFIRM SIGN E IS TO SCALE AND NOTE.

R5 JG 8/28/20 Update elev. Remove 2 logos, and letters, Update clearance no copy or logo. add dimmer required to wall sign and monument

Colors Depicted In This Rendering May Not Match Actual Finished Materials. Refer To Product Samples For Exact Color Match.

Client Approval/Date: \_\_\_\_\_  
Landlord Approval/Date: \_\_\_\_\_

R6 JG 8/31/20 Update CLEARANCE COPY


Account Rep: Fiona Paul  
Project Manager: Jeremy Moore  
Drawn By: Jeshan Delcano/CHC

UL Underwriters Laboratories Inc. ncc  
ELECTRICAL TO USE U.L. LISTED COMPONENTS AND SHALL MEET ALL N.E.C. STANDARDS  
ALL ELECTRICAL SIGNS ARE TO COMPLY WITH U.L. 48 AND ARTICLE 600 OF THE N.E.C. STANDARDS, INCLUDING THE PROPER GROUNDING AND BONDING OF ALL SIGNS.

Project / Location: Store#: 1366  
317 MAIN ST  
MADISON, NJ 07940

Job Number: 23-55534-10  
Date: September 06, 2019  
Sheet Number: 7 Of 14  
Design Number: 23-55534-10 R6

This original drawing is provided as part of a planned project and is not to be exhibited, copied or reproduced without the written permission of Federal Heath Sign Company, LLC or its authorized agent. © FHSC

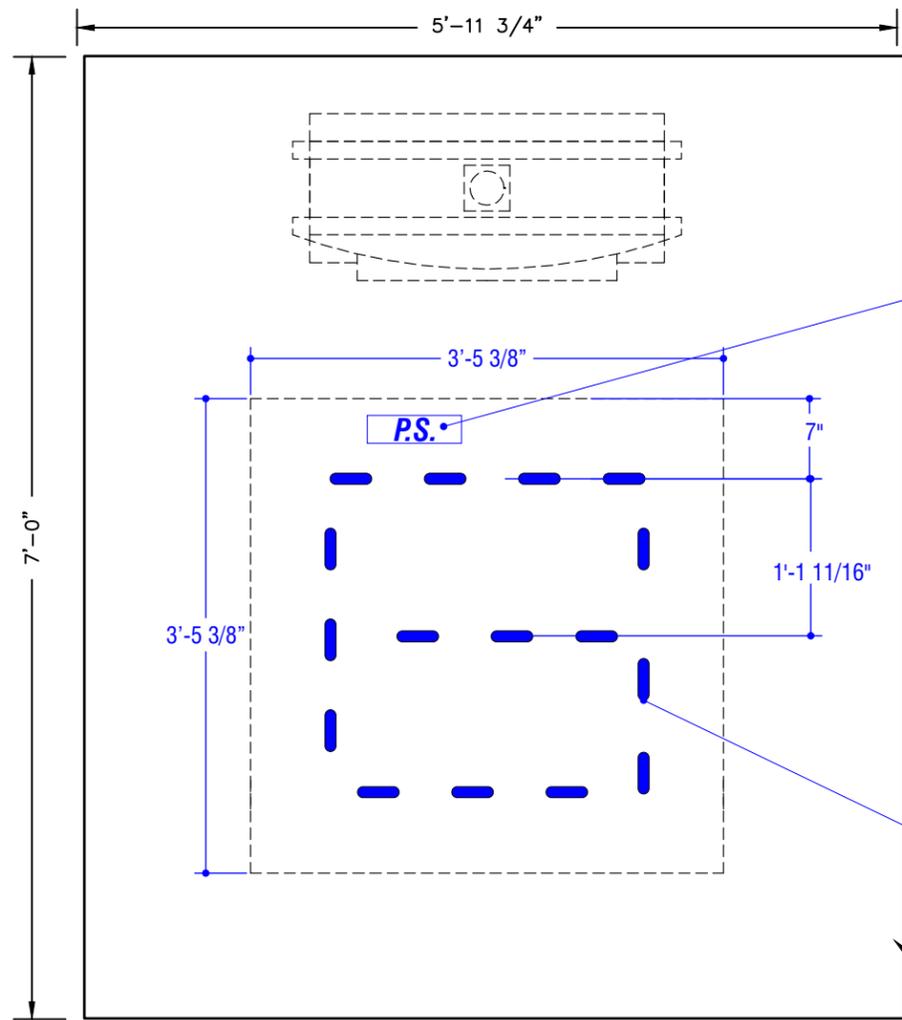


**NOTE: L.E.D.'S MODULES AND POWER SUPPLIES ARE @ INTERIOR OF THE ROOF LIGHT COMPARTMENT**


( 1 ) ONE GEPS24-25 POWER SUPPLY TOTAL: ( 1 ) ONE

WHITE 24V GE TETRA MAX TOTAL: 11'-0"

FAB. ALUM. SWING AWAY/MANUAL RETURN CANOPY

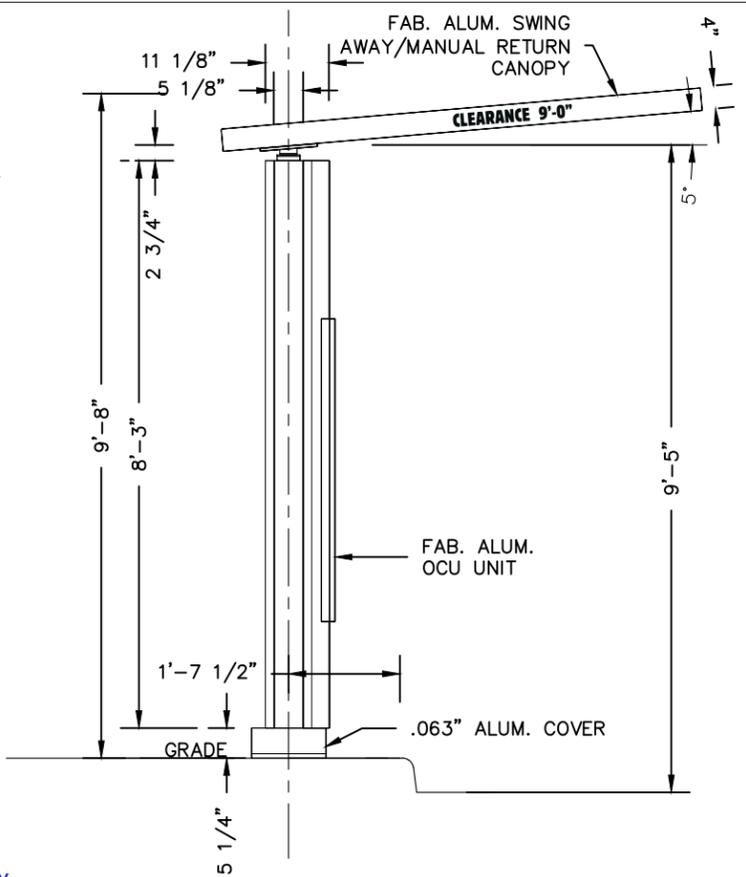


**2 END**  
SCALE: 3/8" = 1'-0"

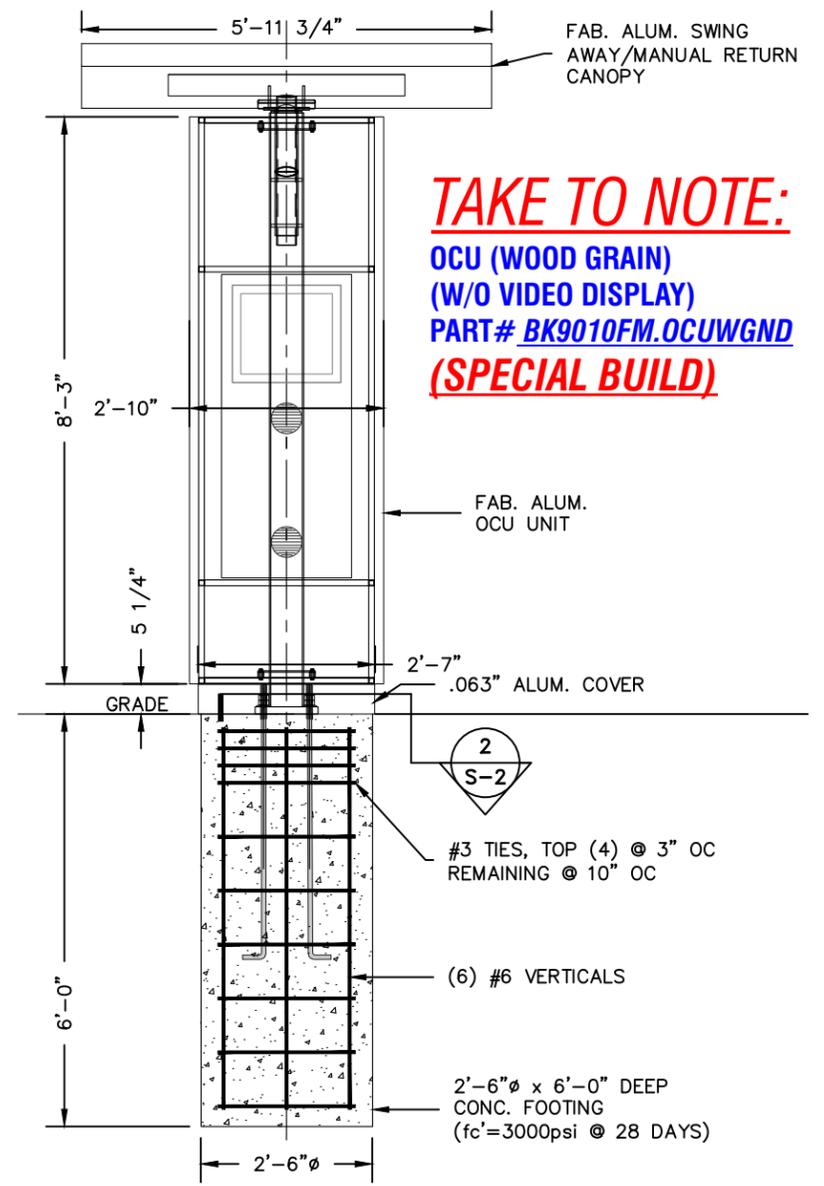


**TAKE TO NOTE:**  
OCU (WOOD GRAIN)  
(W/O VIDEO DISPLAY)  
PART# **BK9010FM.OCUWGND**  
**(SPECIAL BUILD)**

**1 OCU ELEVATION SECTION**  
SCALE: 3/8" = 1'-0"

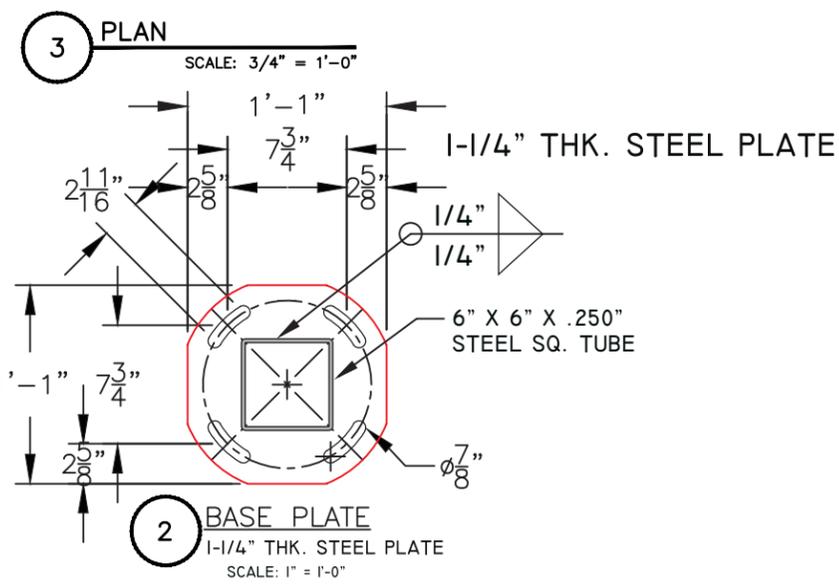

**2 BASE PLATE**  
1-1/4" THK. STEEL PLATE  
SCALE: 1" = 1'-0"

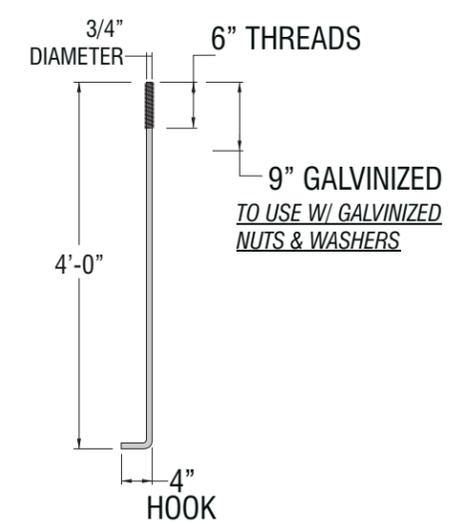

**4 ANCHOR ROD DETAIL (TYP.)**  
SCALE: 1/2" = 1'-0"

**GENERAL NOTES:**

1. CONTRACTOR SHALL VERIFY ALL DIMENSIONS AND CONDITIONS ON JOB SITE.
2. STRUCTURAL STEEL PIPE SHALL CONFORM TO NOTED SPECIFICATIONS.
3. STRUCTURAL STEEL SHAPES AND PLATES SHALL CONFORM TO ASTM A36.
4. WELDING SHALL CONFORM TO AWS D 1.1 & AISC SPECS.
5. ALL WELDING TO BE PERFORMED BY CERTIFIED WELDER.
6. ISOLATE ALUMINUM FROM STEEL.
7. ALL BOLT HOLES TO BE DRILLED OR PUNCHED.
8. SIGNS TO BE 6-FT HORIZONTAL & 12-FT VERTICAL FROM HIGH VOLTAGE WIRES.
9. CONCRETE TO HAVE f'c=3000 PSI MIN. @ 28 DAYS.
10. DESIGN IS BASED ON 175 MPH WIND, 3-SEC GUST, EXPOSURE C.

OCU (WOOD GRAIN)  
(W/O VIDEO DISPLAY)  
PART#  
**BK9010FM.OCUWGND**

OCU (WOOD GRAIN)  
(W/O VIDEO DISPLAY)  
PART#  
**BK9010FM.OCUWGND**

FILE NAME: 2019\_BK 9010FM.OCUWGND(NO VIDEO DISPLAY)

**FEDERAL HEATH**  
VISUAL COMMUNICATIONS  
www.FederalHeath.com  
12704 DuPont Circle Tampa, FL 33626  
(813) 855-4415 (800) 284-3284 Fax (813) 854-3037

Manufacturing Facilities:  
Oceanside, CA - Eules, TX - Jacksonville, TX - San Antonio, TX - Delaware, OH - Racine, WI  
Office Locations:  
Oceanside, CA - Las Vegas, NV - Laughlin, AZ - Idaho Falls, ID - Eules, TX - Jacksonville, TX - San Antonio, TX - Houston, TX - Corpus Christi, TX - Indianapolis, IN - Louisville, KY - Knoxville, TN - Grafton, WI - Delaware, OH - Willowbrook, IL - Tunica, MS - Atlanta, GA - Tampa, FL - Daytona Beach, FL - Orlando, FL

Revisions:  
R1 JK 3/19/20 NEW SITE PLAN & ELEVATIONS  
R2 JK 3/20/20 ADD SIGN F  
R3 JK 5/21/20 ADD ADDITIONAL SPECIFICATIONS FOR MONUMENT SIGN (F)  
R4 JK 6/05/20 CONFIRM SIGN E IS TO SCALE AND NOTE.  
R5 JG 8/28/20 Update elev. Remove 2 logos, and letters, Update clearance no copy or logo. add dimmer required to wall sign and monument  
R6 JG 8/31/20 Update CLEARANCE COPY  
Colors Depicted In This Rendering May Not Match Actual Finished Materials. Refer To Product Samples For Exact Color Match.  
Client Approval/Date: \_\_\_\_\_  
Landlord Approval/Date: \_\_\_\_\_





Account Rep: **Fiona Paul**  
Project Manager: **Jeremy Moore**  
Drawn By: **Jesthan Delcano/CHC**  
Underwriters Laboratories Inc. ncc  
ELECTRICAL TO USE U.L. LISTED COMPONENTS AND SHALL MEET ALL N.E.C. STANDARDS  
ALL ELECTRICAL SIGNS ARE TO COMPLY WITH U.L. 48 AND ARTICLE 600 OF THE N.E.C. STANDARDS, INCLUDING THE PROPER GROUNDING AND BONDING OF ALL SIGNS.

Project / Location:  
**BURGER KING**  
Store#: 1366  
317 MAIN ST  
MADISON, NJ 07940

Job Number: **23-55534-10**  
Date: **September 06, 2019**  
Sheet Number: **8** Of **14**  
Design Number: **23-55534-10 R6**

This original drawing is provided as part of a planned project and is not to be exhibited, copied or reproduced without the written permission of Federal Heath Sign Company, LLC or its authorized agent. © FHSC

OCU (WOOD GRAIN)  
(W/O VIDEO DISPLAY)  
PART#  
**BK9010FM.OCUWGND**

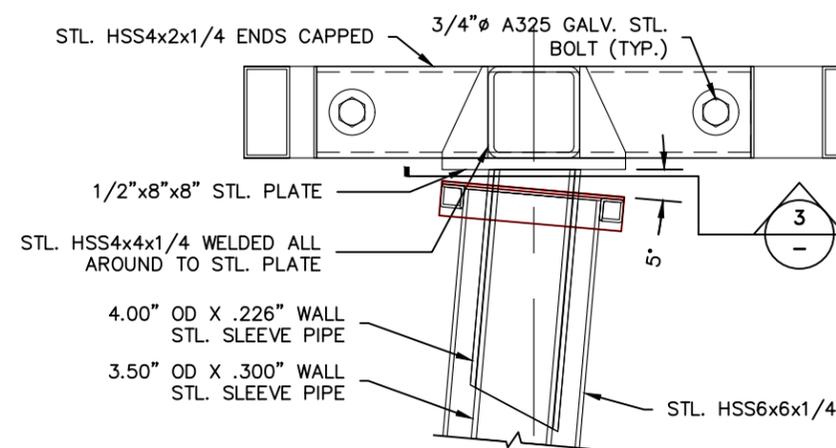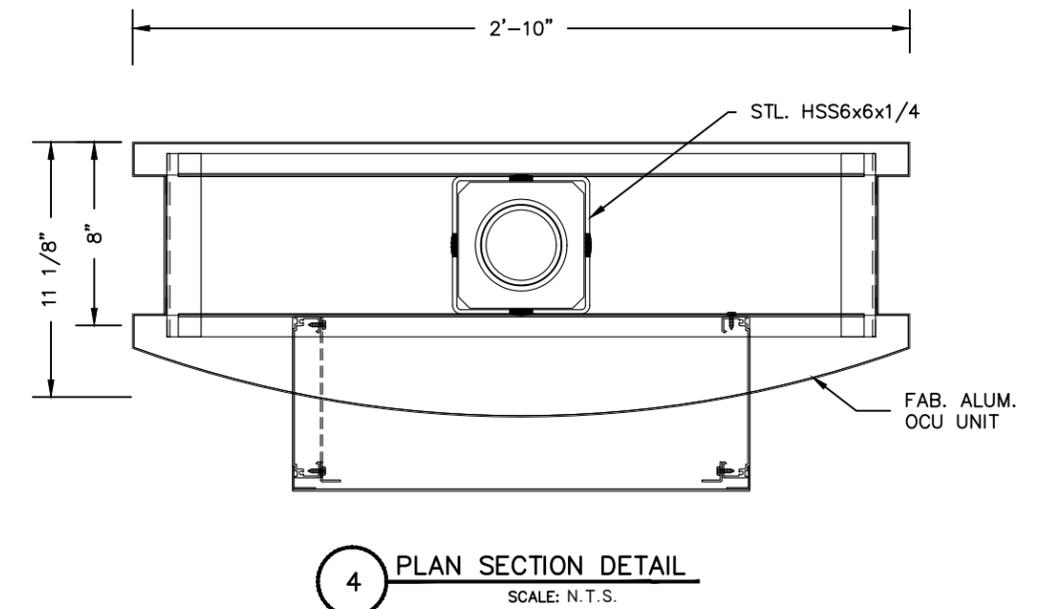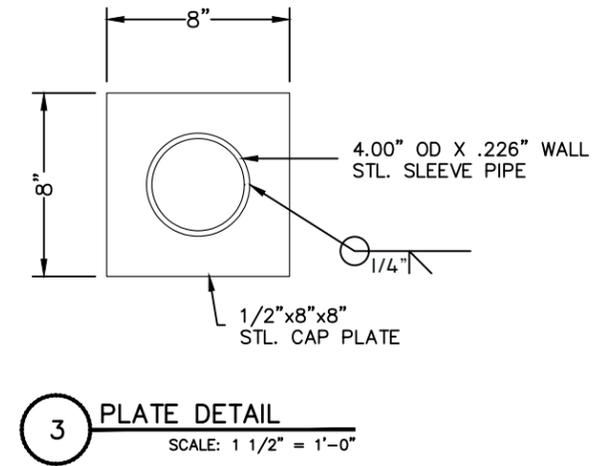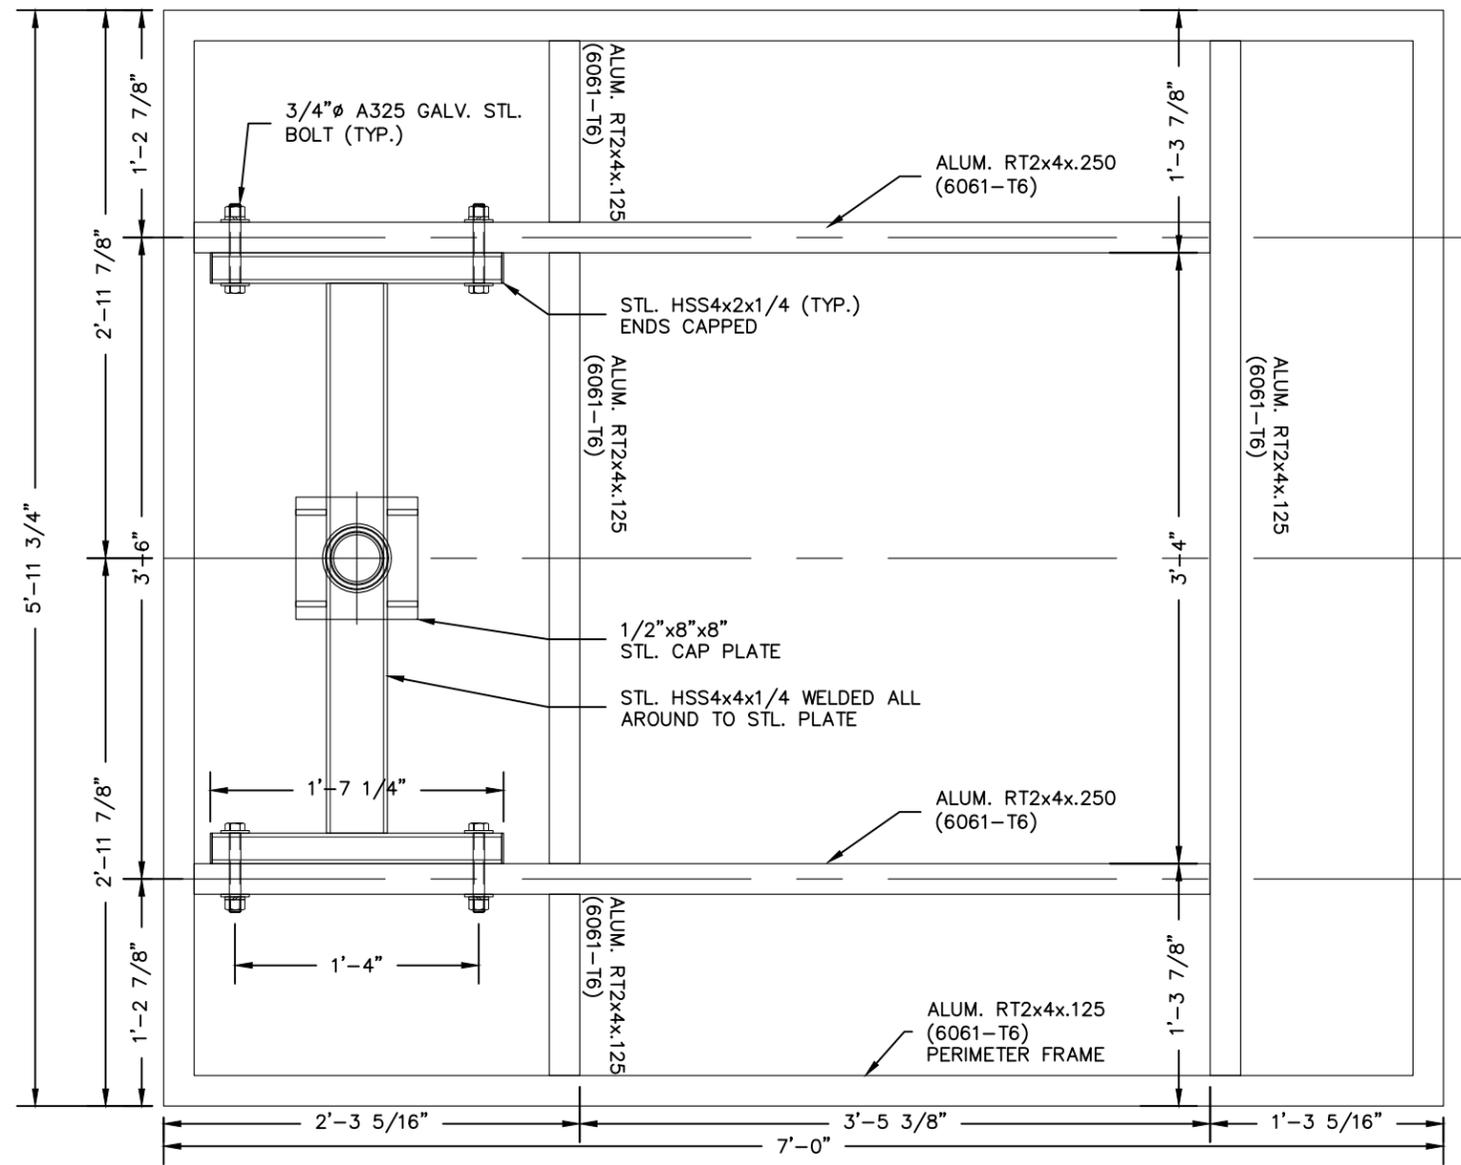

OCU (WOOD GRAIN)  
(W/O VIDEO DISPLAY)  
PART#  
**BK9010FM.OCUWGND**

FILE NAME: 2019\_BK 9010FM.OCUWGND(NO VIDEO DISPLAY)

**FEDERAL HEATH**  
VISUAL COMMUNICATIONS  
www.FederalHeath.com  
12704 DuPont Circle Tampa, FL 33626  
(813) 855-4415 (800) 284-3284 Fax (813) 854-3037

Manufacturing Facilities:  
Oceanside, CA - Eules, TX - Jacksonville, TX  
Delaware, OH - Racine, WI  
Office Locations:  
Oceanside, CA - Las Vegas, NV - Laughlin, AZ  
Idaho Falls, ID - Eules, TX - Jacksonville, TX - San Antonio, TX  
Houston, TX - Corpus Christi, TX - Indianapolis, IN  
Louisville, KY - Knoxville, TN - Grafton, WI - Delaware, OH  
Willowbrook, IL - Tunica, MS - Atlanta, GA  
Tampa, FL - Daytona Beach, FL - Orlando, FL

Revisions:  
R1 JK 3/12/20 NEW SITE PLAN & ELEVATIONS  
R2 JK 3/20/20 ADD SIGN F  
R3 JK 5/21/20 ADD ADDITIONAL SPECIFICATIONS FOR MONUMENT SIGN (F)  
R4 JK 6/05/20 CONFIRM SIGN E IS TO SCALE AND NOTE.  
R5 JG 8/28/20 Update elev. Remove 2 logos, and letters, Update clearance no copy or logo. add dimmer required to wall sign and monument.  
R6 JG 8/31/20 Update CLEARANCE COPY

Colors Depicted In This Rendering May Not Match Actual Finished Materials. Refer To Product Samples For Exact Color Match.

Client Approval/Date: \_\_\_\_\_  
Landlord Approval/Date: \_\_\_\_\_

Account Rep: **Fiona Paul**  
Project Manager: **Jeremy Moore**  
Drawn By: **Jesthan Delcano/CHC**  
Underwriters Laboratories Inc. ncc  
ELECTRICAL TO USE U.L. LISTED COMPONENTS AND SHALL MEET ALL N.E.C. STANDARDS  
ALL ELECTRICAL SIGNS ARE TO COMPLY WITH U.L. 48 AND ARTICLE 600 OF THE N.E.C. STANDARDS, INCLUDING THE PROPER GROUNDING AND BONDING OF ALL SIGNS.

Project / Location:  
**BURGER KING**  
Store#: 1366  
317 MAIN ST  
MADISON, NJ 07940

Job Number: **23-55534-10**  
Date: **September 06, 2019**  
Sheet Number: **9** Of **14**  
Design Number: **23-55534-10 R6**

This original drawing is provided as part of a planned project and is not to be exhibited, copied or reproduced without the written permission of Federal Heath Sign Company, LLC or its authorized agent. © FHSC

**NON-STANDARD**

LOGO REMOVED AND COPY CHANGED

**STANDARD  
CLEARANCE BAR  
PART #  
BK9009FM.20 CLWG**



**NOTE:**  
CLADDING/ STEEL SUPPORT: STEEL CONTINGENT ON ENGINEERS SPEC. AND WIND  
LOAD REQUIREMENTS STEEL BASE PLATE W/STEEL ANCHOR BOLTS AND CONCRETE  
FOUNDATION

ANCHOR BOLT FOUNDATION SHOULD BE PROVIDED BY ENGINEER FOR LOCAL WIND  
LOAD REQUIREMENTS

CLEARANCE BAR CAN  
ONLY BE REMOVED WITH  
BKC APPROVAL

CLEARANCE BAR COLORS  
TO MATCH OCU PER  
LOCATION

AUTO RETURN  
CLEARANCE BAR  
(SEE ISOVIEW FOR  
DETAIL)

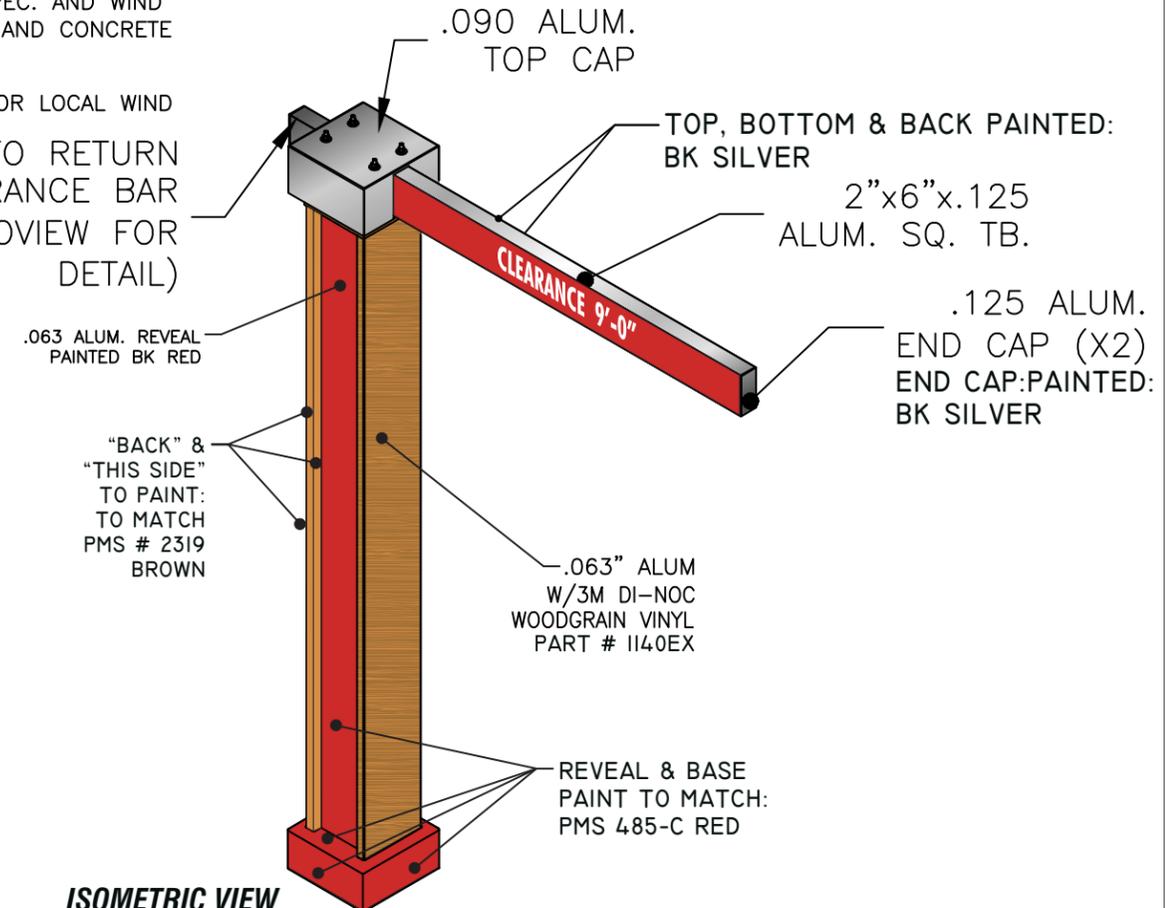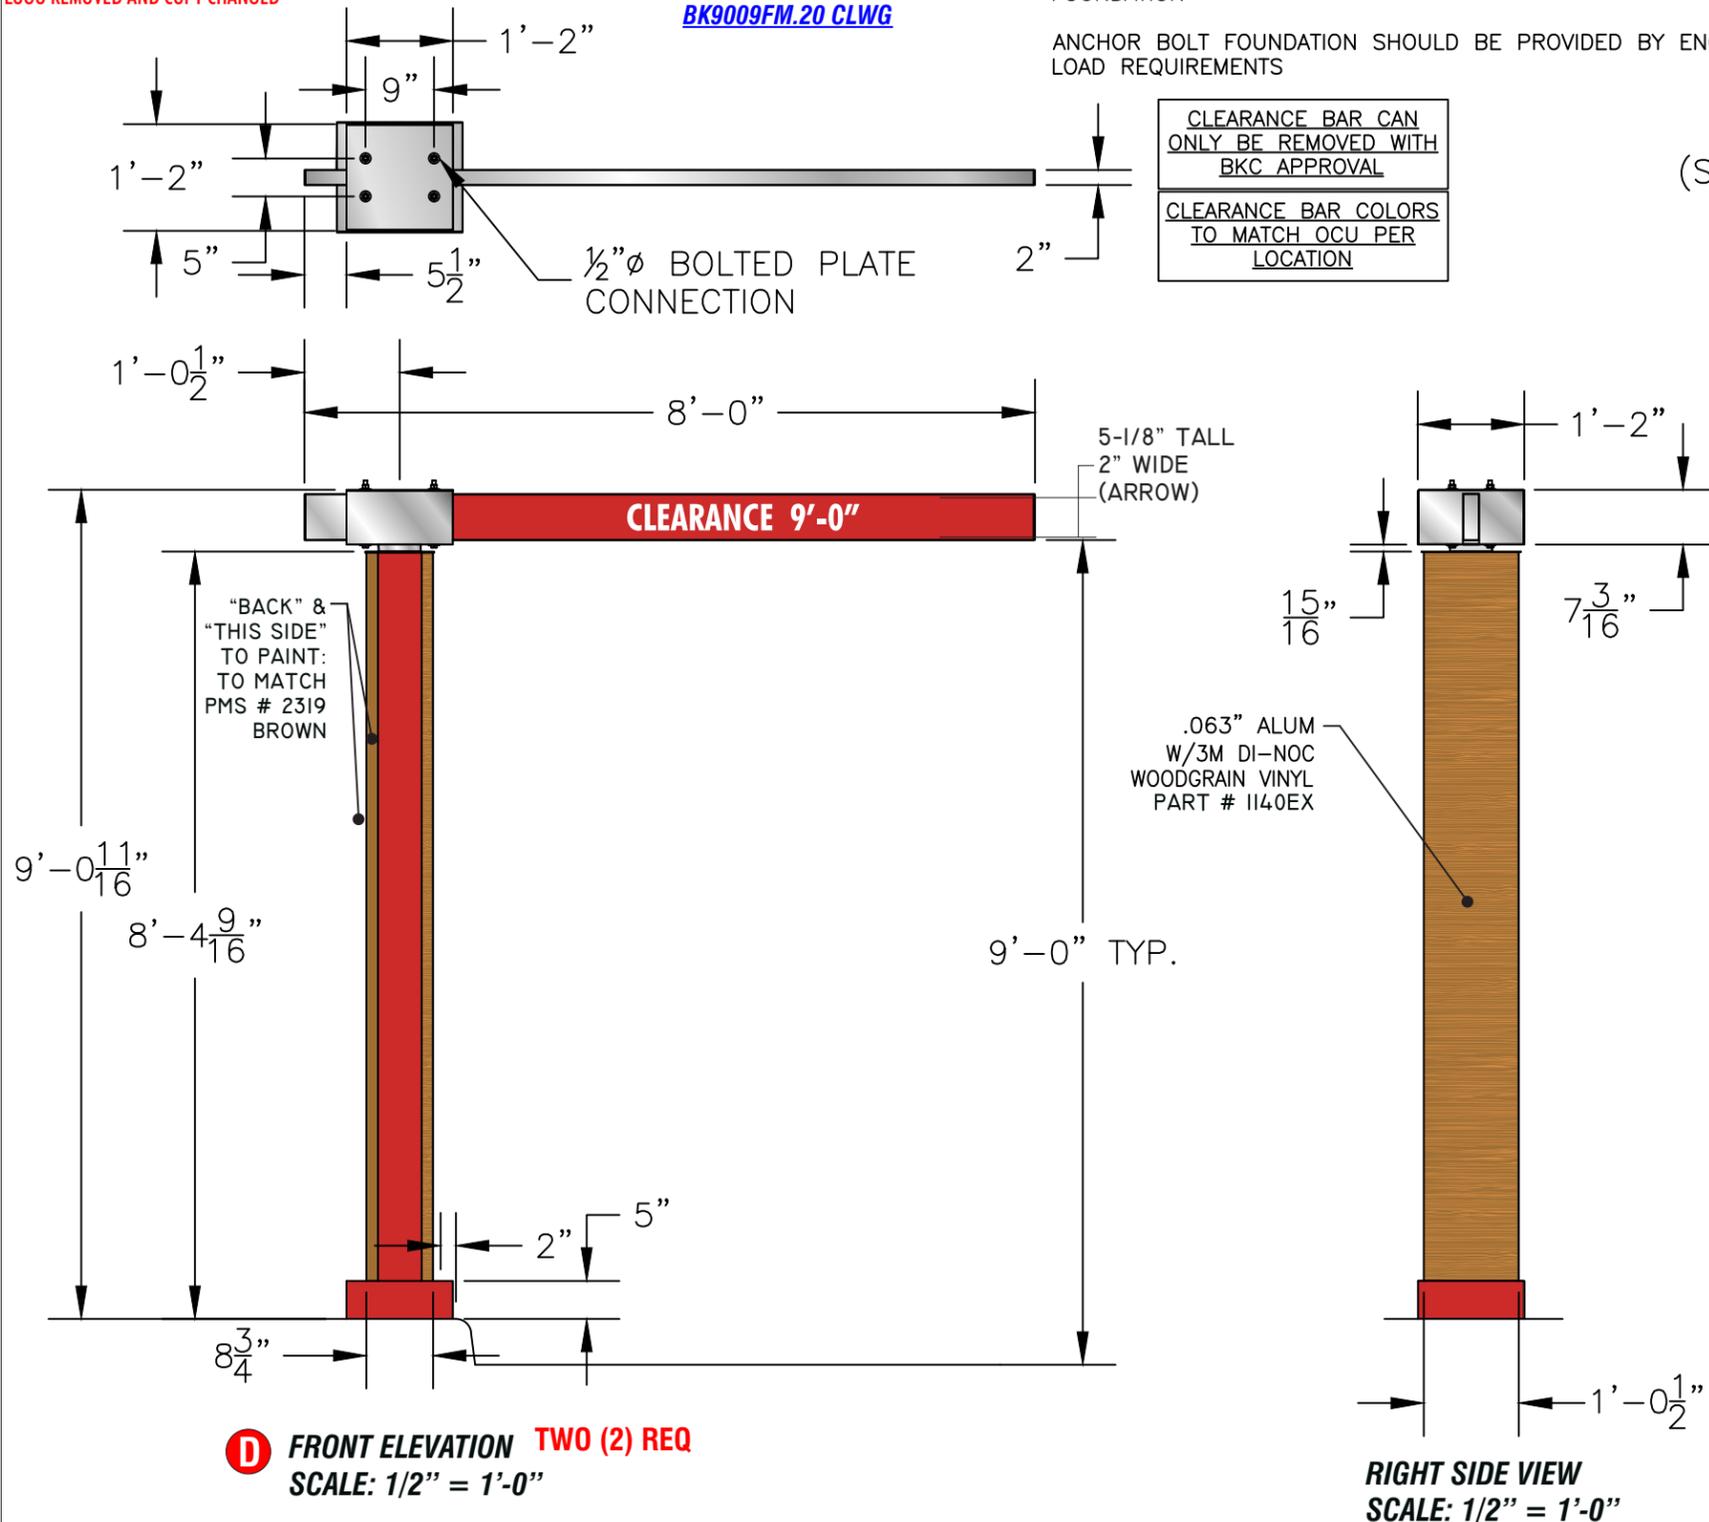

**COLOR NOTES:**  
FRONT PANEL: .063" ALUM W/3M DI-NOC WOODGRAIN VINYL PART # 1140EX  
BACK PANEL: WOODGRAIN VINYL PART # 1140EX  
REVEAL: PAINT BK RED  
CLEARANCE BAR: BRUSHED ALUM FINISH w/REFLECTIVE SILVER VINYL (SIDES)  
BASE: PAINT BK RED



**STANDARD  
CLEARANCE BAR  
PART #  
BK9009FM.20 CLWG**

FILE NAME: BK9009FM.20CLCLEARANCE BAR{UD\_I\_24\_2019}.CDR

**FEDERAL HEATH**  
VISUAL COMMUNICATIONS  
www.FederalHeath.com  
12704 DuPont Circle Tampa, FL 33626  
(813) 855-4415 (800) 284-3284 Fax (813) 854-3037

Manufacturing Facilities:  
Oceanside, CA - Eules, TX - Jacksonville, TX  
Delaware, OH - Racine, WI

Office Locations:  
Oceanside, CA - Las Vegas, NV - Laughlin, AZ  
Idaho Falls, ID - Eules, TX - Jacksonville, TX - San Antonio, TX  
Houston, TX - Corpus Christi, TX - Indianapolis, IN  
Louisville, KY - Knoxville, TN - Grafton, WI - Delaware, OH  
Willowbrook, IL - Tunica, MS - Atlanta, GA  
Tampa, FL - Daytona Beach, FL - Orlando, FL

Revisions:  
R1 JCR 3/19/20 NEW SITE PLAN & ELEVATIONS  
R2 JCR 3/20/20 ADD SIGN "F"  
R3 JK 5/21/20 ADD ADDITIONAL SPECIFICATIONS FOR MONUMENT SIGN (F)  
R4 JK 6/05/20 CONFIRM SIGN E IS TO SCALE AND NOTE.

R5 JG 8/28/20 Update elev. Remove 2 logos, and letters, Update clearance no copy or logo. add dimmer required to wall sign and monument

Colors Depicted In This Rendering May Not Match Actual Finished Materials. Refer To Product Samples For Exact Color Match.

Client Approval/Date: \_\_\_\_\_  
Landlord Approval/Date: \_\_\_\_\_

R6 JG 8/31/20 Update CLEARANCE COPY

Account Rep: Fiona Paul  
Project Manager: Jeremy Moore  
Drawn By: Jeshan Delcano/CHC

**UL** Underwriters Laboratories Inc. **nec** ELECTRICAL TO USE U.L. LISTED COMPONENTS AND SHALL MEET ALL N.E.C. STANDARDS  
ALL ELECTRICAL SIGNS ARE TO COMPLY WITH U.L. 48 AND ARTICLE 600 OF THE N.E.C. STANDARDS, INCLUDING THE PROPER GROUNDING AND BONDING OF ALL SIGNS.



Project / Location: **BURGER KING**

Store #: 1366  
317 MAIN ST  
MADISON, NJ 07940


Job Number: 23-55534-10  
Date: September 06, 2019  
Sheet Number: 10 Of 14  
Design Number: 23-55534-10 R6

This original drawing is provided as part of a planned project and is not to be exhibited, copied or reproduced without the written permission of Federal Heath Sign Company, LLC or its authorized agent. © FHSC

**STANDARD  
CLEARANCE BAR  
PART #  
BK9009FM.20 CLWG**

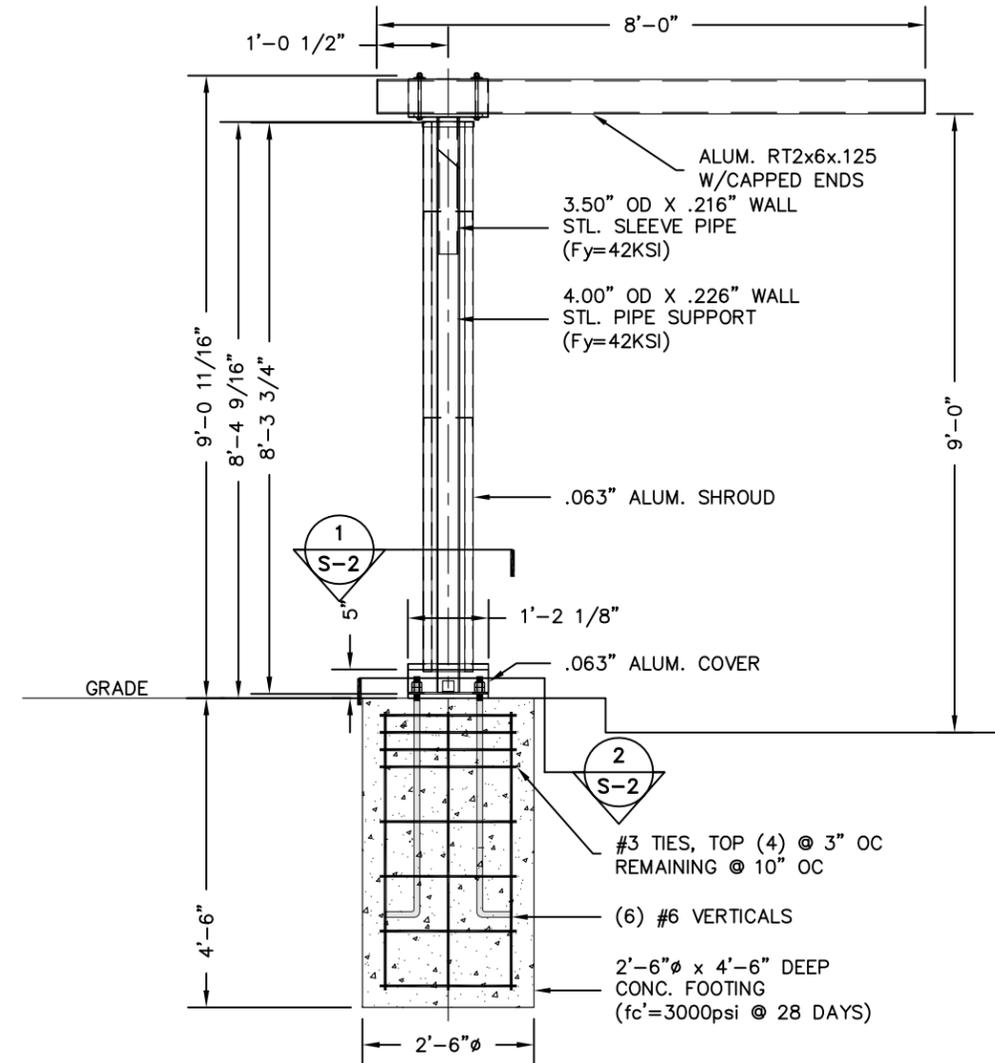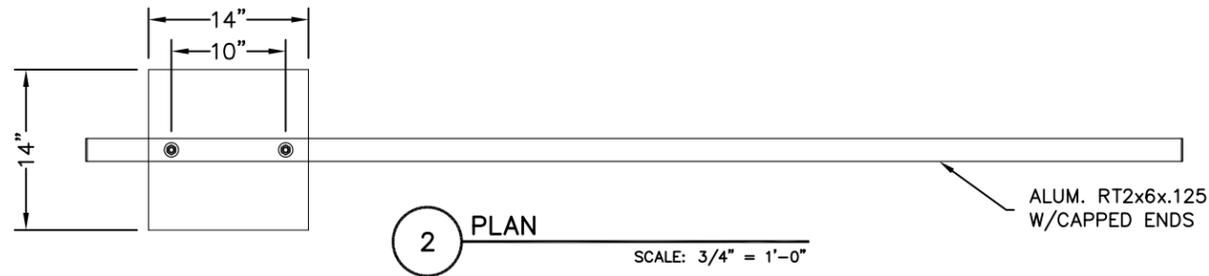

**1 CLEARANCE BAR ELEVATION SECTION**  
SCALE: 3/8" = 1'-0"

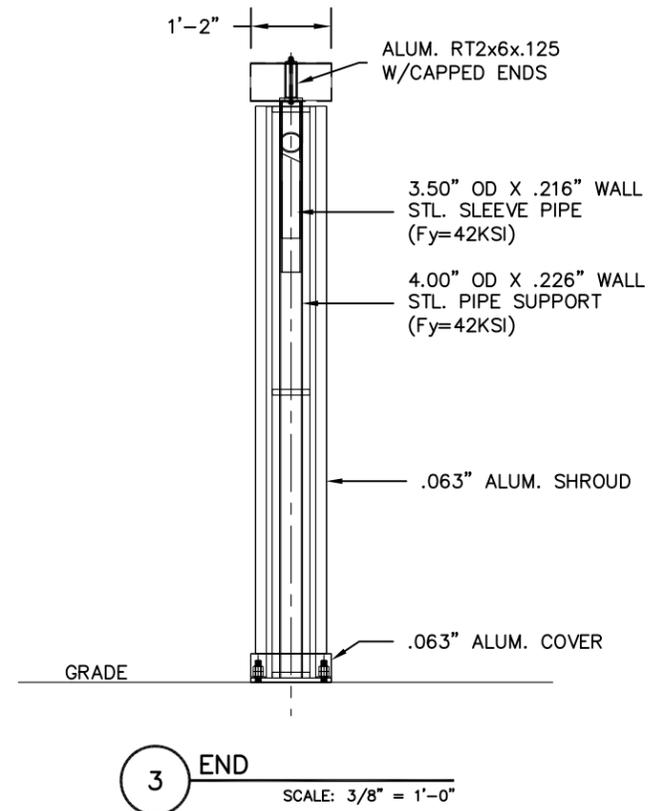

**3 END**  
SCALE: 3/8" = 1'-0"

**GENERAL NOTES:**


1. CONTRACTOR SHALL VERIFY ALL DIMENSIONS AND CONDITIONS ON JOB SITE.
2. STRUCTURAL STEEL PIPE SHALL CONFORM TO NOTED SPECIFICATIONS.
3. STRUCTURAL STEEL SHAPES AND PLATES SHALL CONFORM TO ASTM A36.
4. WELDING SHALL CONFORM TO AWS D 1.1 & AISC SPECS.
5. ALL WELDING TO BE PERFORMED BY CERTIFIED WELDER.
6. ISOLATE ALUMINUM FROM STEEL.
7. ALL BOLT HOLES TO BE DRILLED OR PUNCHED.
8. SIGNS TO BE 6-FT HORIZONTAL & 12-FT VERTICAL FROM HIGH VOLTAGE WIRES.
9. CONCRETE TO HAVE  $f'_c=3000$  PSI MIN. @ 28 DAYS.
10. DESIGN IS BASED ON 175 MPH WIND, 3-SEC GUST, EXPOSURE C.

\\OCEANSIDE-DC\Oceanside-S1\B\Burger King\NEW OCU & CLEARANCE 9.4.18\BK CLEARANCE 2018 DESIGN.dwg

FILE NAME: BK9009FM.20CLCLEARANCE BAR{UD\_I-24\_2019}.CDR

**STANDARD  
CLEARANCE BAR  
PART #  
BK9009FM.20 CLWG**

**STANDARD CLEARANCE BAR**  
**PART # BK9009FM.20CLWG**

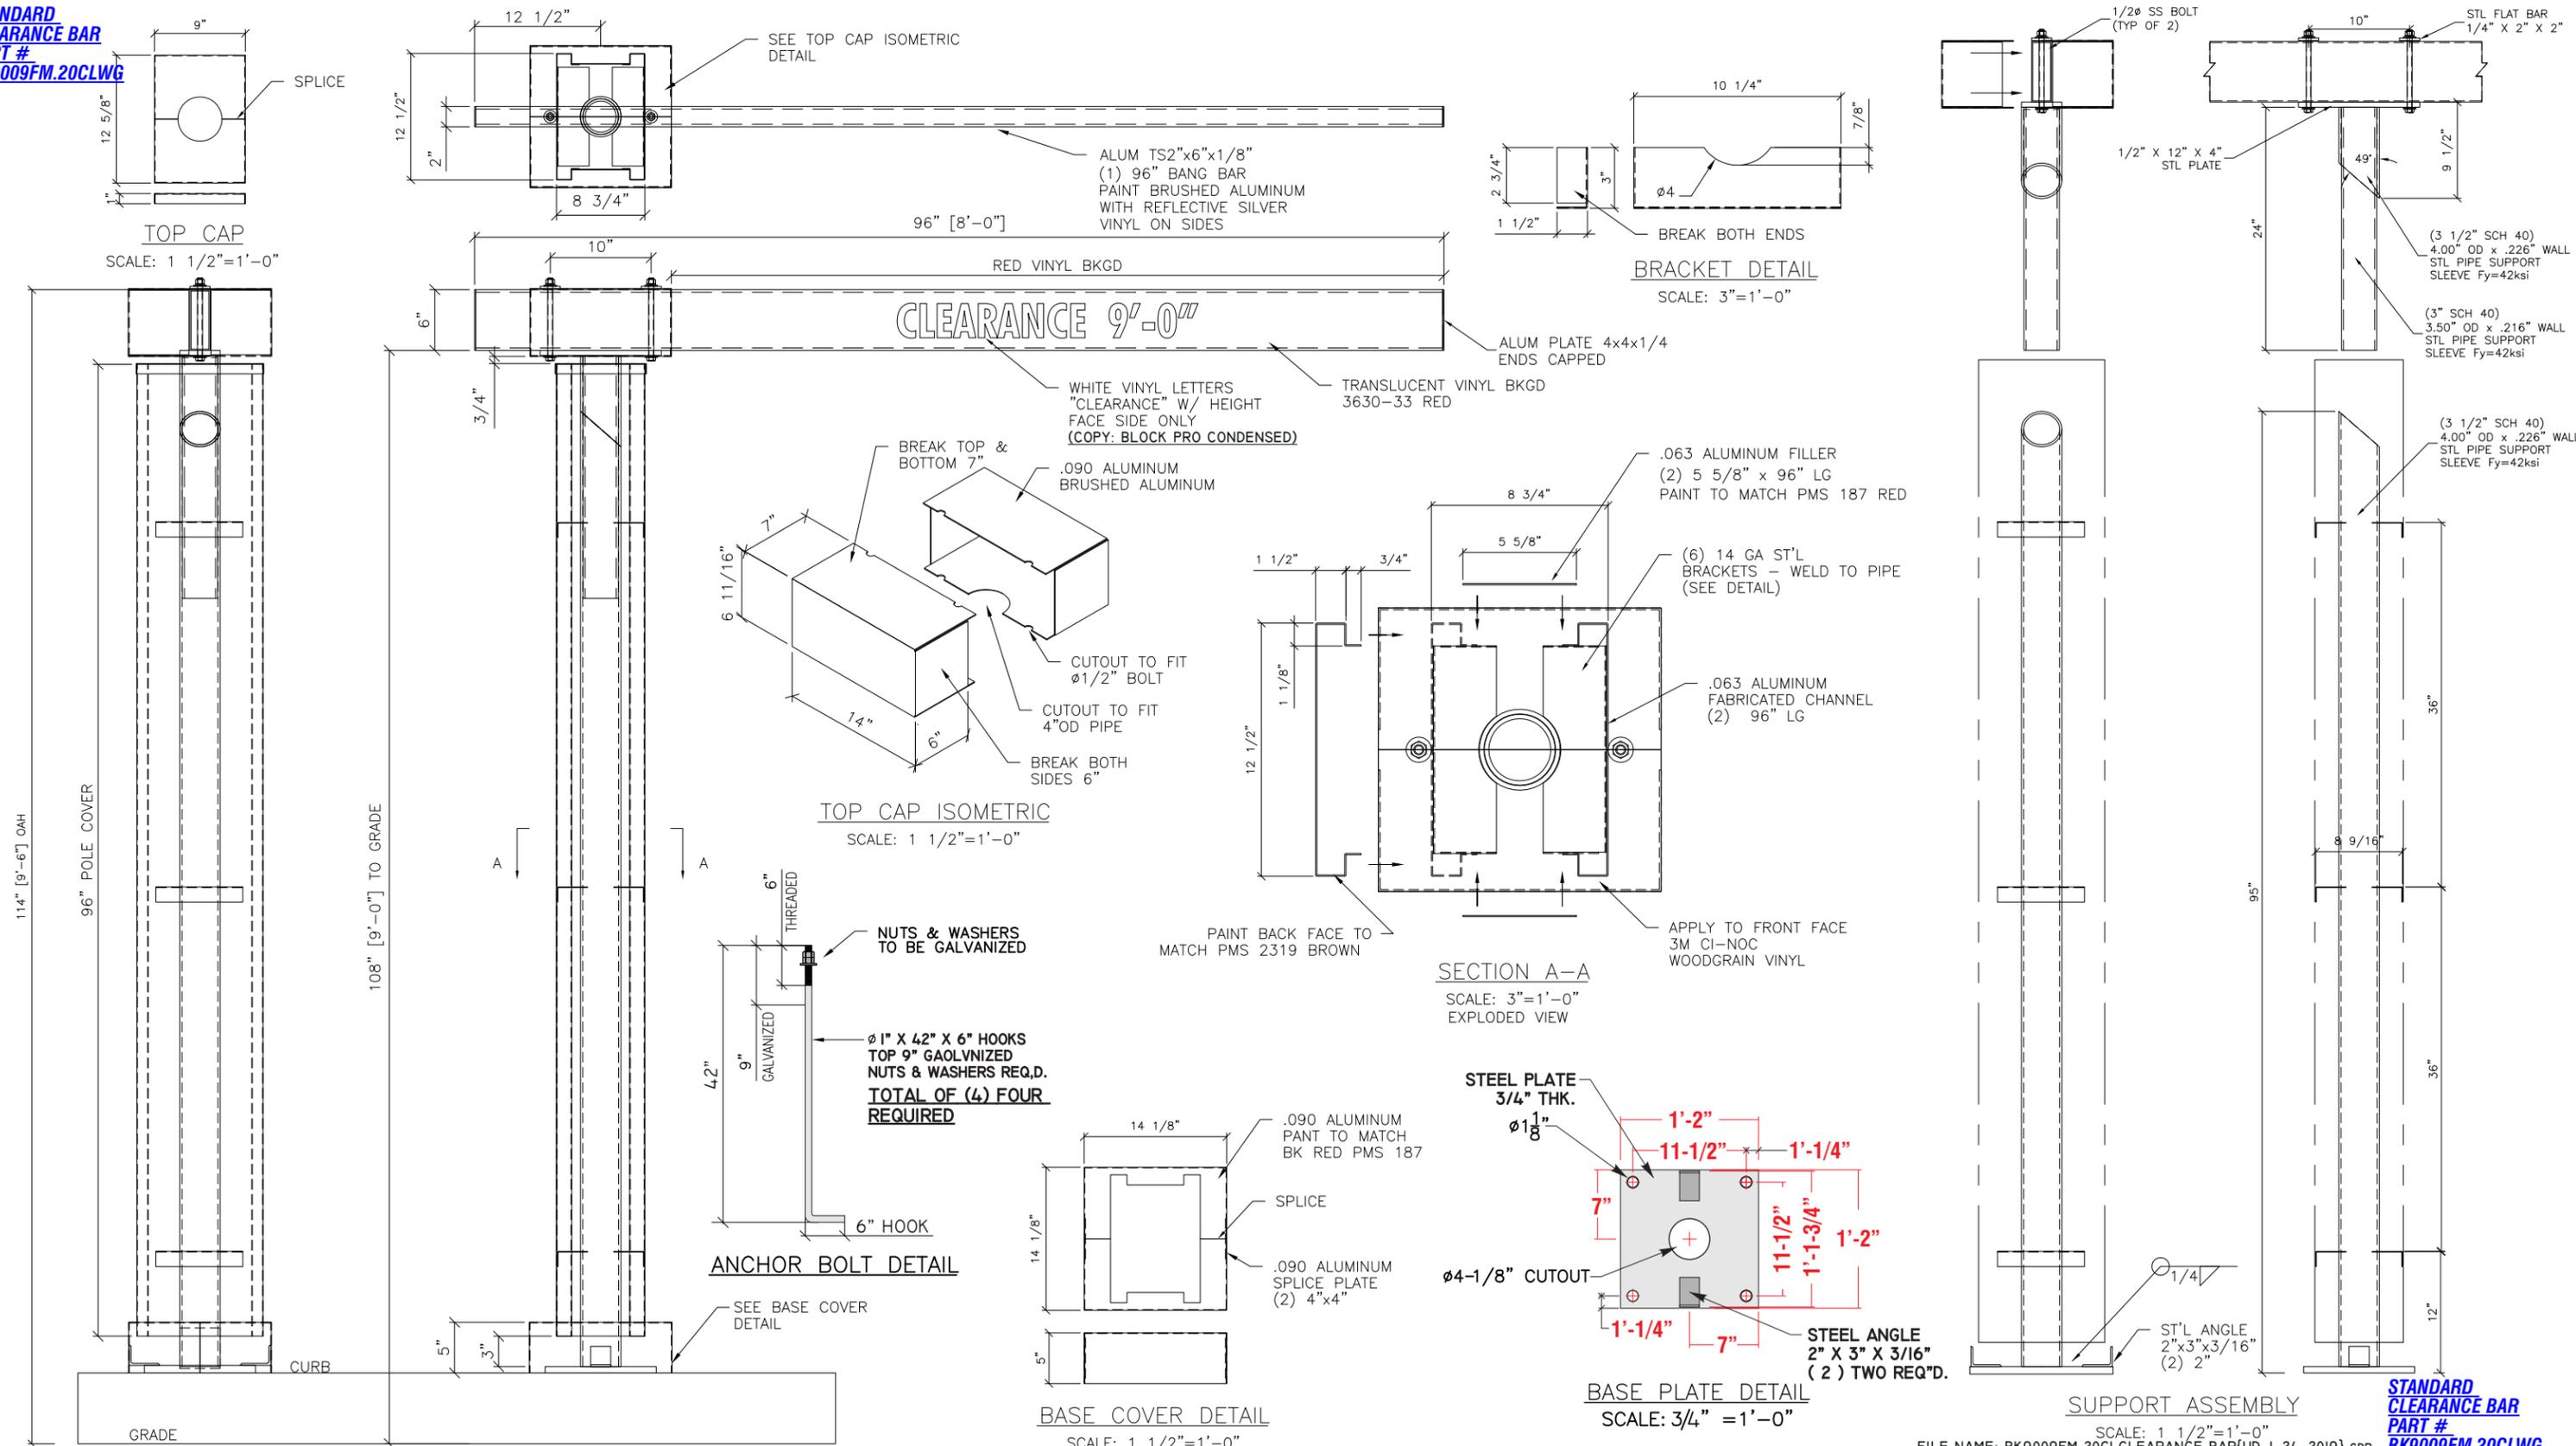

FILE NAME: BK9009FM.20CLWCLEARANCE BAR(UD\_1.24\_2019).cdr

**FEDERAL HEATH**  
**VISUAL COMMUNICATIONS**  
 www.FederalHeath.com  
 12704 DuPont Circle Tampa, FL 33626  
 (813) 855-4415 (800) 284-3284 Fax (813) 854-3037

Manufacturing Facilities:  
 Oceanside, CA - Eules, TX - Jacksonville, TX  
 Delaware, OH - Racine, WI

Office Locations:  
 Oceanside, CA - Las Vegas, NV - Laughlin, AZ  
 Idaho Falls, ID - Eules, TX - Jacksonville, TX - San Antonio, TX  
 Houston, TX - Corpus Christi, TX - Indianapolis, IN  
 Louisville, KY - Knoxville, TN - Grafton, WI - Delaware, OH  
 Willowbrook, IL - Tunica, MS - Atlanta, GA  
 Tampa, FL - Daytona Beach, FL - Orlando, FL

Revisions:  
 R1 JK 3/12/20 NEW SITE PLAN & ELEVATIONS  
 R2 JK 3/20/20 ADD SIGN F  
 R3 JK 5/21/20 ADD ADDITIONAL SPECIFICATIONS FOR MONUMENT SIGN (F)  
 R4 JK 6/05/20 CONFIRM SIGN E IS TO SCALE AND NOTE.

R6 JG 8/31/20 Update CLEARANCE COPY

R5 JG 8/28/20 Update elev. Remove 2 logos, and letters, Update clearance no copy or logo. add dimmer required to wall sign and monument

Colors Depicted In This Rendering May Not Match Actual Finished Materials. Refer To Product Samples For Exact Color Match.

Client Approval/Date: \_\_\_\_\_  
 Landlord Approval/Date: \_\_\_\_\_

Account Rep: **Fiona Paul**  
 Project Manager: **Jeremy Moore**  
 Drawn By: **Jesthan Delcano/CHC**

**UL** Underwriters Laboratories Inc. **nec** ELECTRICAL TO USE U.L. LISTED COMPONENTS AND SHALL MEET ALL N.E.C. STANDARDS  
 ALL ELECTRICAL SIGNS ARE TO COMPLY WITH U.L. 48 AND ARTICLE 600 OF THE N.E.C. STANDARDS, INCLUDING THE PROPER GROUNDING AND BONDING OF ALL SIGNS.

Project / Location: **BURGER KING**

Store #: 1366  
 317 MAIN ST  
 MADISON, NJ 07940

Job Number: **23-55534-10**  
 Date: **September 06, 2019**  
 Sheet Number: **12** Of **14**  
 Design Number: **23-55534-10 R6**

This original drawing is provided as part of a planned project and is not to be exhibited, copied or reproduced without the written permission of Federal Heath Sign Company, LLC or its authorized agent. © FHSC

Drawing Type Art Creative  
 Customer Burger King  
 Project Description 1 X 3 Digital Drive-Thru Spec.  
 © 2018 LSI GRAPHIC SOLUTIONS

Drawn By: DL  
 Proj. Man.:  
 Date: 07/25/18  
 Proj. No.:


Note: 1) Housing Constructed of Aluminum Extrusion  
 2) Entire Board and Steel Powder Coat Black  
 MATERIALS: All Joints To Be Welded All Around  
 Grade A36 Steel Shapes  
 Grade A500 B Steel Tube




## NOTE: MENU'S BY OTHERS

### E MENU DISPLAYS

TWO(2) REQUIRED  
 scale 3/4" = 1'-0"

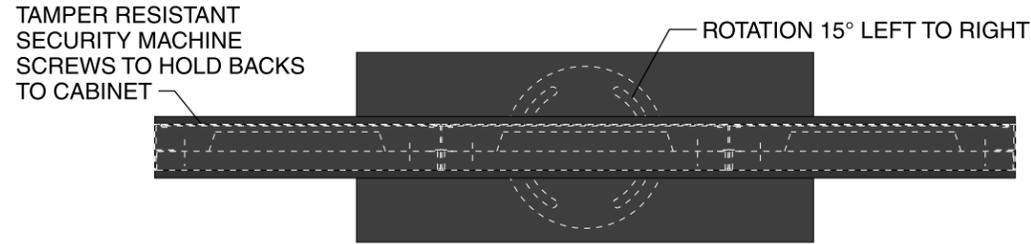




★ Unit can be installed on existing foundation and anchor bolts, and if preferred can utilize the existing mounting steel base.  
 (This would require the data cables to be routed outside of the existing mounting steel.)

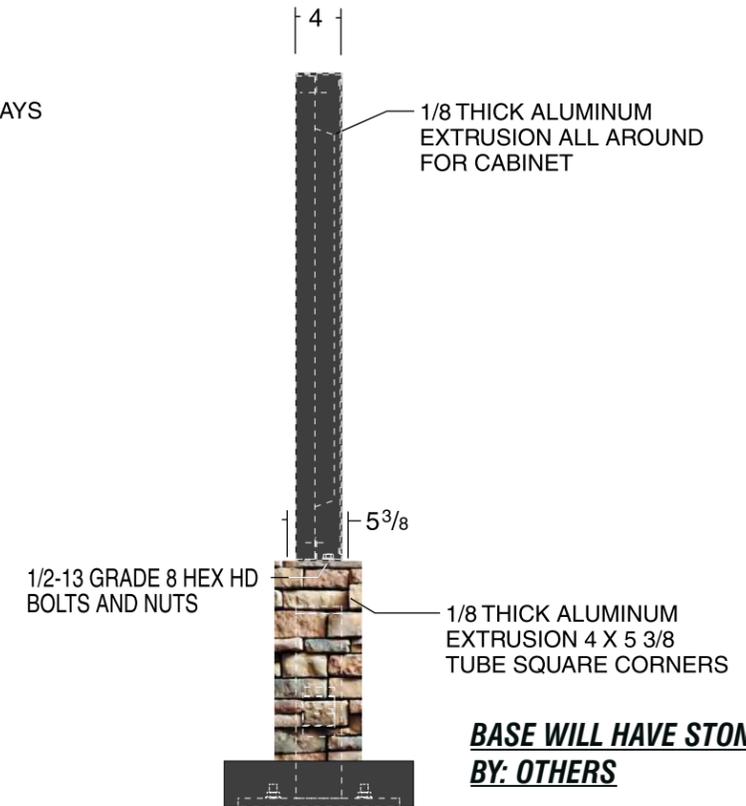

**BASE WILL HAVE STONE WORK BY: OTHERS**

**NOTE: The completed menu board is CUL / UL listed.**

★ These are approximate foundation measurements. The soil bearing capacity at the erection site must be considered when designing the foundation. The sign manufacturer is not able to predetermine the specific needs of each location. Consult a local engineer for design specifications.

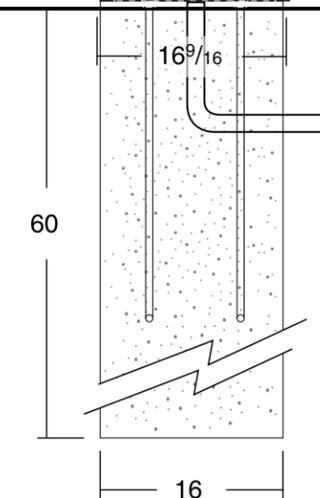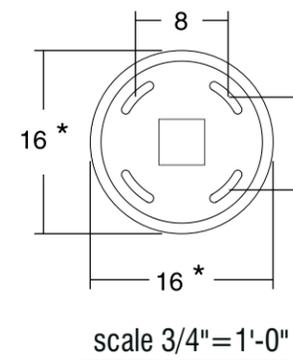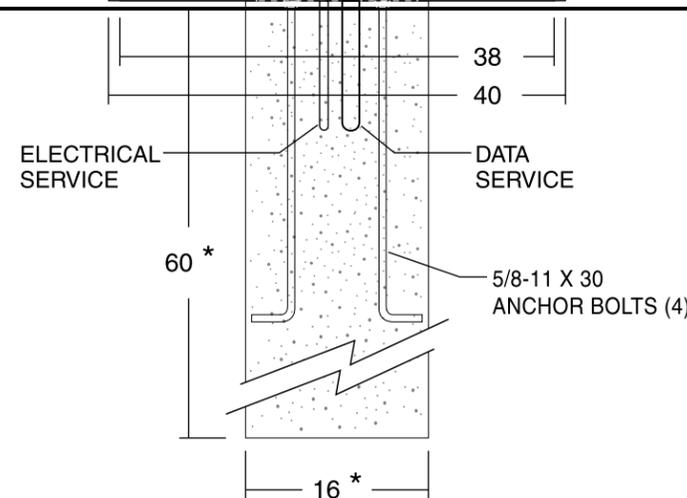

**Electrical:**  
 13.5 Amps @ 120 VAC 60 Hz

**DESIGN INTENT ONLY**  
**ENGINEERING REQUIRED TO DETERMINE**  
**ACTUAL MANUFACTURING**  
**& INSTALLATION REQUIREMENTS**


**NON-STANDARD**

DIMMER SWITCH REQUIRED

COLOR NOTES:  
 ILLUM. REVEAL: .125 RED PCB  
 RND CAB. FILLER/ RETAINER:  
 PAINT BRUSHED ALUM. SILVER  
 RETAINER/EXPOSED LENS RETAINER:  
 PAINT PMS 2319 (BROWN)  
 MON FACE PANEL: .090" ALUM

LOGO FACE: .093 CLEAR PCB  
 BUN LOGO: 3M 3630-125 YELLOW  
 ACCENT RING: 3M 3630-8703 BLUE  
 COPY/ RTM: 3M 3630-33 RED  
 BKG'D/ BUN ACCENT: 3M 3635-30  
 WHITE DIFFUSER  
 \*\*\*VINYL TO BE APPLIED 2nd SURFACE\*\*\*

ELECTRICAL NOTE—ACTUAL # OF CIRCUITS TO BE  
 DETERMINED BY A LICENSED ELECTRICAL CONTRACTOR.  
 TOTAL AMPS: 1.1  
 # OF CKTS: 1 @ 20 AMP(RECOMMENDED)  
 VOLTS: 120  
 ELECTRICAL CONNECTION AS FOLLOWS:  
 GREEN TO GREEN (GROUND), WHITE TO WHITE (NEUTRAL),  
 BLACK TO BLACK (POWER)  
 ALL SIGNAGE WILL BE (U.L.) LISTED, (U.L.) 2161 COMPLIANT  
 AND CARRY (U.L) LABELS.

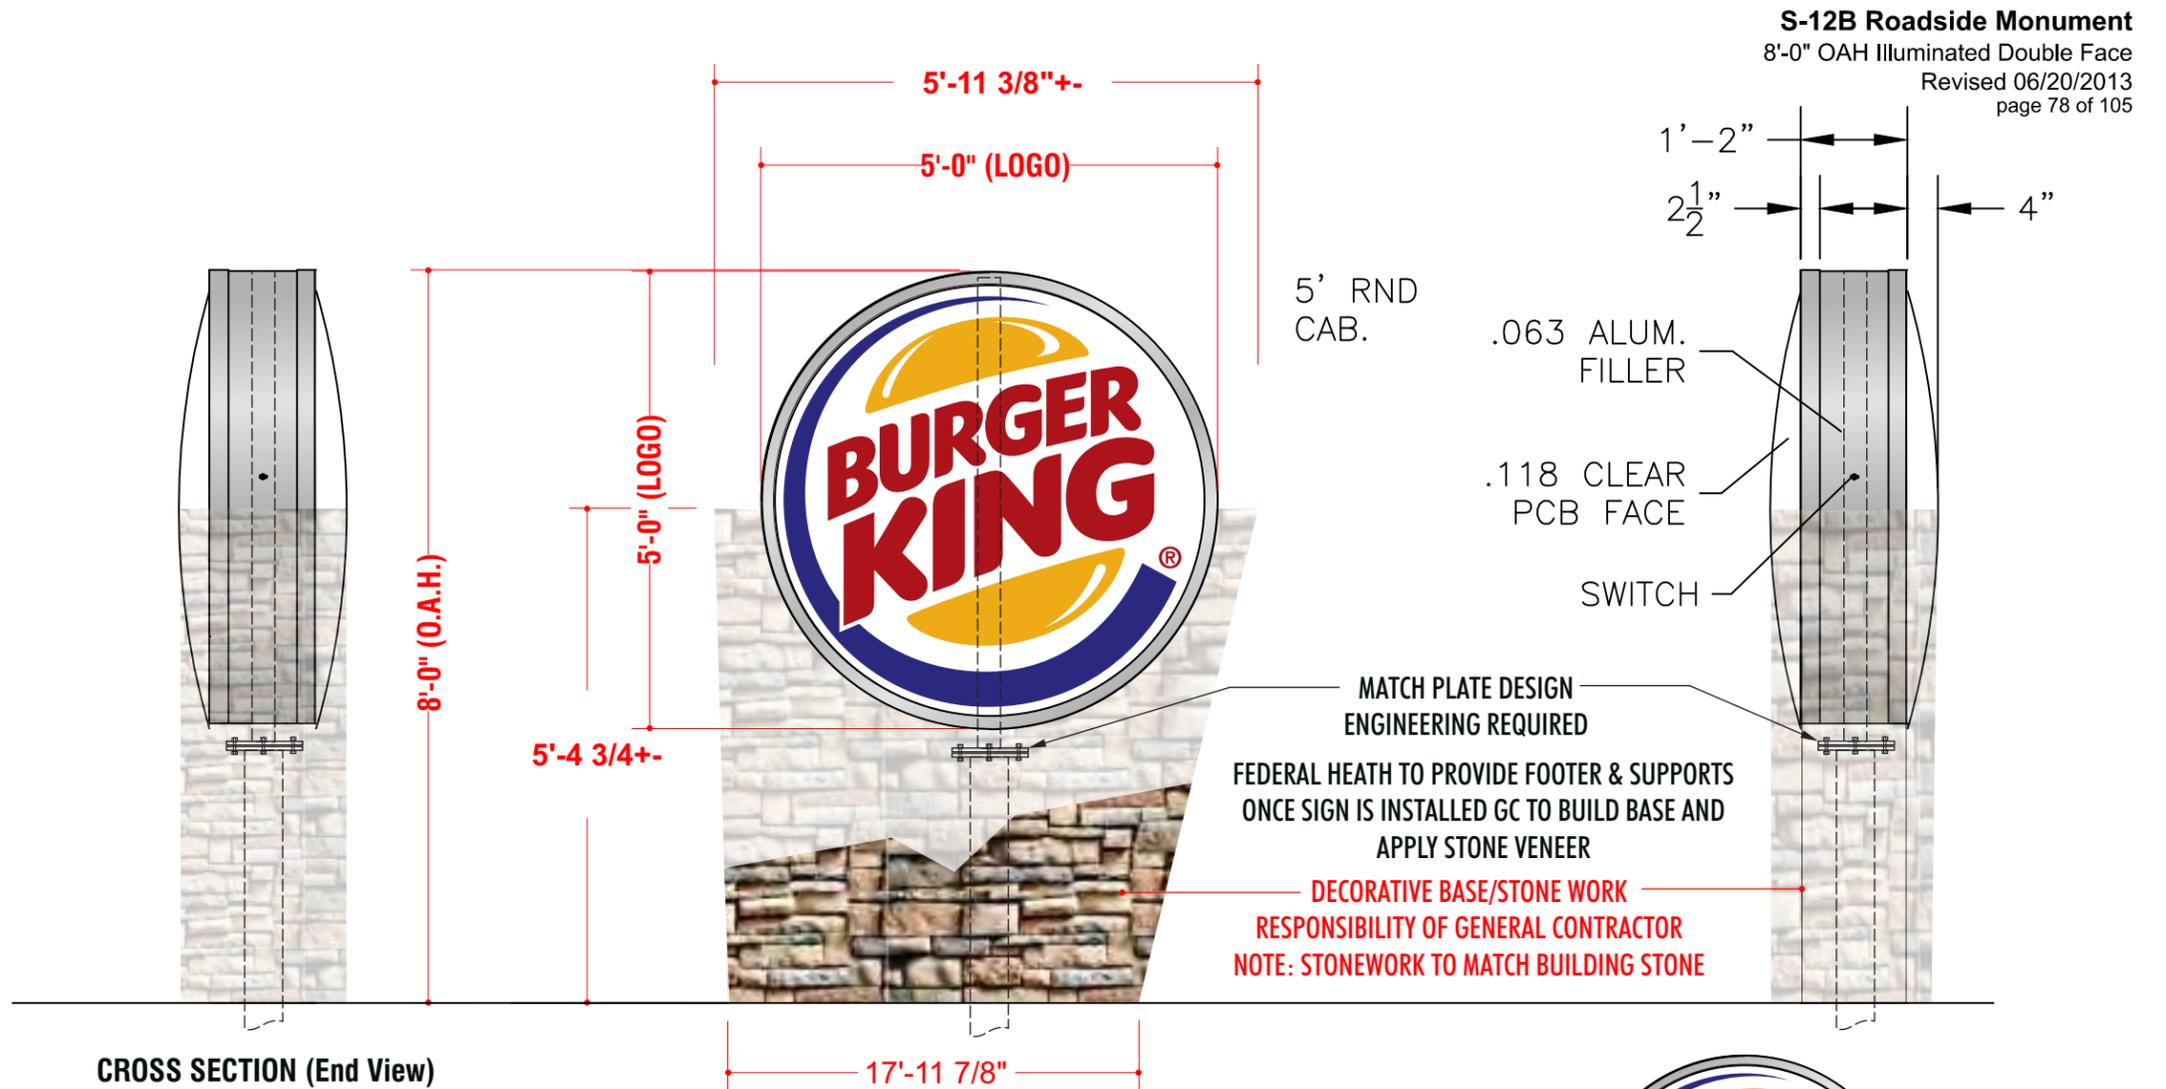

CROSS SECTION (End View)

**F DOUBLE FACED INTERNALLY ILLUMINATED MONUMENT SIGN**

scale 1/4"=1'-0"

LOGO  
 19.6 SQUARE FEET



\*NOTE:  
 INSTALL TOGGLE SWITCH TO OPERATE  
 (ON/OFF) IN THE HORIZONTAL POSITION.



OPPOSITE SIDE

**FEDERAL HEATH**  
**VISUAL COMMUNICATIONS**  
 www.FederalHeath.com  
 12704 DuPont Circle Tampa, FL 33626  
 (813) 855-4415 (800) 284-3284 Fax (813) 854-3037

Manufacturing Facilities:  
 Oceanside, CA - Eules, TX - Jacksonville, TX - San Antonio, TX  
 Delaware, OH - Racine, WI  
 Office Locations:  
 Oceanside, CA - Las Vegas, NV - Laughlin, AZ  
 Idaho Falls, ID - Eules, TX - Jacksonville, TX - San Antonio, TX  
 Houston, TX - Corpus Christi, TX - Indianapolis, IN  
 Louisville, KY - Knoxville, TN - Grafton, WI - Delaware, OH  
 Willowbrook, IL - Tunica, MS - Atlanta, GA  
 Tampa, FL - Daytona Beach, FL - Orlando, FL

Revisions:  
 R1 JCR 3/19/20 NEW SITE PLAN & ELEVATIONS  
 R2 JCR 3/20/20 ADD SIGN F  
 R3 JK 5/21/20 ADD ADDITIONAL SPECIFICATIONS FOR MONUMENT SIGN (F)  
 R4 JK 6/05/20 CONFIRM SIGN E IS TO SCALE AND NOTE.  
 R5 JG 8/28/20 Update elev. Remove 2 logos, and letters, Update clearance no copy or logo.  
 add dimmer required to wall sign and monument  
 Colors Depicted In This Rendering May Not Match Actual Finished Materials. Refer To Product Samples For Exact Color Match.  
 Client Approval/Date: \_\_\_\_\_  
 Landlord Approval/Date: \_\_\_\_\_

R6 JG 8/31/20 Update CLEARANCE COPY

Account Rep: Fiona Paul  
 Project Manager: Jeremy Moore  
 Drawn By: Jeshan Delcano/CHC  
 Underwriters Laboratories Inc. ncc  
 ELECTRICAL TO USE U.L. LISTED COMPONENTS AND SHALL MEET ALL N.E.C. STANDARDS  
 ALL ELECTRICAL SIGNS ARE TO COMPLY WITH U.L. 48 AND ARTICLE 600 OF THE N.E.C. STANDARDS, INCLUDING THE PROPER GROUNDING AND BONDING OF ALL SIGNS.

Project / Location:  
  
 Store#: 1366  
 317 MAIN ST  
 MADISON, NJ 07940

Job Number: 23-55534-10  
 Date: September 06, 2019  
 Sheet Number: 14 Of 14  
 Design Number: 23-55534-10 R6

This original drawing is provided as part of a planned project and is not to be exhibited, copied or reproduced without the written permission of Federal Heath Sign Company, LLC or its authorized agent. © FHSC